



DISH Wireless L.L.C. SITE ID:

BOBOS00341B

DISH Wireless L.L.C. SITE ADDRESS:

**1 BRATTLE SQUARE
CAMBRIDGE, MA 02138**

MASSACHUSETTS CODE COMPLIANCE

ALL WORK SHALL BE PERFORMED AND MATERIALS INSTALLED IN ACCORDANCE WITH THE CURRENT EDITIONS OF THE FOLLOWING CODES AS ADOPTED BY THE LOCAL GOVERNING AUTHORITIES. NOTHING IN THESE PLANS IS TO BE CONSTRUED TO PERMIT WORK NOT CONFORMING TO THESE CODES:

CODE TYPE	CODE
BUILDING	MA STATE BUILDING CODE, 10TH EDITION (780 CMR)/2021 IBC W/ AMENDMENTS
MECHANICAL	MECHANICAL CODE 2021 OF MASSACHUSETTS/2021 IMC W/ AMENDMENTS
ELECTRICAL	MA ELECTRICAL CODE/2023 NEC W/ AMENDMENTS

SHEET INDEX

SHEET NO.	SHEET TITLE
T-1	TITLE SHEET
A-1	BUILDING PLAN
A-2	ANTENNA PLAN, ELEVATION AND SCHEDULE
A-3	BUILDING ELEVATION
A-4	EQUIPMENT PLATFORM AND H-FRAME DETAILS
A-5	EQUIPMENT DETAILS
A-6	EQUIPMENT DETAILS
E-1	ELECTRICAL/FIBER ROUTE PLAN AND NOTES
E-2	ELECTRICAL DETAILS
E-3	ELECTRICAL ONE-LINE & PANEL SCHEDULE
G-1	GROUNDING PLANS AND NOTES
G-2	GROUNDING DETAILS
G-3	GROUNDING DETAILS
RF-1	RF CABLE COLOR CODE
GN-1	LEGEND AND ABBREVIATIONS
GN-2	RF SIGNAGE
GN-3	GENERAL NOTES
GN-4	GENERAL NOTES
GN-5	GENERAL NOTES
GN-6	PMI CHECKLIST & NOTES
ST-1	ANTENNA BALLAST FRAME & CONCEALMENT PLAN
ST-2	CONNECTION DETAILS & CONCEALMENT ELEVATION
ST-3	BILL OF MATERIALS

SCOPE OF WORK

THIS IS NOT AN ALL INCLUSIVE LIST. CONTRACTOR SHALL UTILIZE SPECIFIED EQUIPMENT PART OR ENGINEER APPROVED EQUIVALENT. CONTRACTOR SHALL VERIFY ALL NEEDED EQUIPMENT TO PROVIDE A FUNCTIONAL SITE. THE PROJECT GENERALLY CONSISTS OF THE FOLLOWING:

SECTOR SCOPE OF WORK:

- INSTALL (3) PROPOSED PANEL ANTENNAS (1 PER SECTOR)
- INSTALL (2) PROPOSED ANTENNA CONCEALMENT MOUNTS (1 PER ALPHA & BETA SECTOR & 1 PER GAMMA SECTOR)
- INSTALL (3) PROPOSED RRH BALLAST MOUNT (1 PER SECTOR)
- INSTALL PROPOSED JUMPERS
- INSTALL (6) PROPOSED RRUS (2 PER SECTOR)
- INSTALL (2) PROPOSED OVER VOLTAGE PROTECTION DEVICE (OVP) (1 PER ALPHA & BETA SECTOR & 1 PER GAMMA SECTOR)
- INSTALL (2) PROPOSED DC POWER CABLES (1 PER ALPHA & BETA SECTOR & 1 PER GAMMA SECTOR)
- INSTALL (2) PROPOSED FIBER TRUNKS (1 PER ALPHA & BETA SECTOR & 1 PER GAMMA SECTOR)

ROOFTOP SCOPE OF WORK:

- INSTALL PROPOSED CABLE TRAY
- INSTALL PROPOSED CEILING LADDER
- INSTALL (1) PROPOSED BBU IN CABINET
- INSTALL (1) PROPOSED FIF RACK
- INSTALL (1) PROPOSED NEMA 3 TELCO-FIBER BOX
- INSTALL (1) PROPOSED ZAYO 5RU, IF REQUIRED
- INSTALL (1) PROPOSED GPS UNIT
- UTILIZE (1) EXISTING POWER PROTECTIVE CABINET
- UTILIZE (1) EXISTING DISCONNECT SWITCH
- UTILIZE (1) EXISTING METER
- UTILIZE EXISTING TRANSFORMER
- UTILIZE EXISTING POWER CONDUIT
- UTILIZE EXISTING FIBER CONDUIT
- UTILIZE EXISTING GROUNDING CONDUIT

SITE PHOTO



UNDERGROUND SERVICE ALERT - 811 DIG SAFE
UTILITY NOTIFICATION CENTER OF MASSACHUSETTS
(888) 344-7233
WWW.DIGSAFE.COM

CALL 3 WORKING DAYS UTILITY NOTIFICATION PRIOR TO CONSTRUCTION

GENERAL NOTES

THE FACILITY IS UNMANNED AND NOT FOR HUMAN HABITATION. A TECHNICIAN WILL VISIT THE SITE AS REQUIRED FOR ROUTINE MAINTENANCE. THE PROJECT WILL NOT RESULT IN ANY SIGNIFICANT DISTURBANCE OR EFFECT ON DRAINAGE. NO SANITARY SEWER SERVICE, POTABLE WATER, OR TRASH DISPOSAL IS REQUIRED AND NO COMMERCIAL SIGNAGE IS PROPOSED.

11"x17" PLOT WILL BE HALF SCALE UNLESS OTHERWISE NOTED

CONTRACTOR SHALL VERIFY ALL PLANS, EXISTING DIMENSIONS, AND CONDITIONS ON THE JOB SITE, AND SHALL IMMEDIATELY NOTIFY THE ENGINEER IN WRITING OF ANY DISCREPANCIES BEFORE PROCEEDING WITH THE WORK.

SITE INFORMATION

PROPERTY OWNER: BC SP 9 OBS PROPERTY LLC
ADDRESS: 1 BRATTLE SQ,
CAMBRIDGE, MA 02138

STRUCTURE TYPE: ROOFTOP

TOWER CO SITE ID: N/A

TOWER APP NUMBER: N/A

COUNTY: MIDDLESEX

LATITUDE (NAD 83): 42° 22' 23.944" N
42.373318 N

LONGITUDE (NAD 83): 71° 07' 17.378" W
71.121494 W

ZONING JURISDICTION: CAMBRIDGE, MA

ZONING DISTRICT: BUSINESS B

PARCEL NUMBER: MAP 168 LOT 36

OCCUPANCY GROUP: U

CONSTRUCTION TYPE: II-B

POWER COMPANY: EVERSOURCE/NSTAR

TELEPHONE COMPANY: COMCAST

PROJECT DIRECTORY

APPLICANT: DISH Wireless L.L.C.
5701 SOUTH SANTA FE DRIVE
LITTLETON, CO 80120

STRUCTURE MANAGER: BC SP 9 OBS PROPERTY LLC
1 BRATTLE SQ,
CAMBRIDGE, MA 02138

SITE DESIGNER: NB+C ENGINEERING SERVICES, LLC
300 UNICORN PARK DRIVE,
SUITE 0501, WOBURN, MA 01801
(978) 856-8308

SITE ACQUISITION: KRISTEN LEDUC
KLEDUC@DISH.COM

CONSTRUCTION MANAGER: AARON CHANDLER
AARON.CHANDLER@DISH.COM


RF ENGINEER: VICTORIEN NDOUNOU
VICTORIEN.NDOUNOU.DISH.COM

DIRECTIONS

DIRECTIONS FROM BOSTON, LOGAN AIRPORT:

HEAD NORTHWEST, TURN LEFT, TURN RIGHT TOWARD LOGAN MEMORIAL WAY, TURN RIGHT ONTO LOGAN MEMORIAL WAY, TURN LEFT ONTO HOTEL DR, TURN RIGHT ONTO TRANSPORTATION WAY TOWARD AIRPORT EXIT/TERMINALS A/B/C/D/EMBASSY SUITES, TURN RIGHT AND TAKE RAMP ONTO I-90 W, TAKE EXIT 131 TOWARD CAMBRIDGE, TURN SLIGHTLY RIGHT ONTO CAMBRIDGE ST, CONTINUE ON RIVER ST, TURN LEFT ONTO MEMORIAL DR, TURN RIGHT ONTO MEMORIAL DR, TURN RIGHT ONTO MT AUBURN ST, TURN LEFT, 1 BRATTLE SQ, CAMBRIDGE, MA 02138.

VICINITY MAP

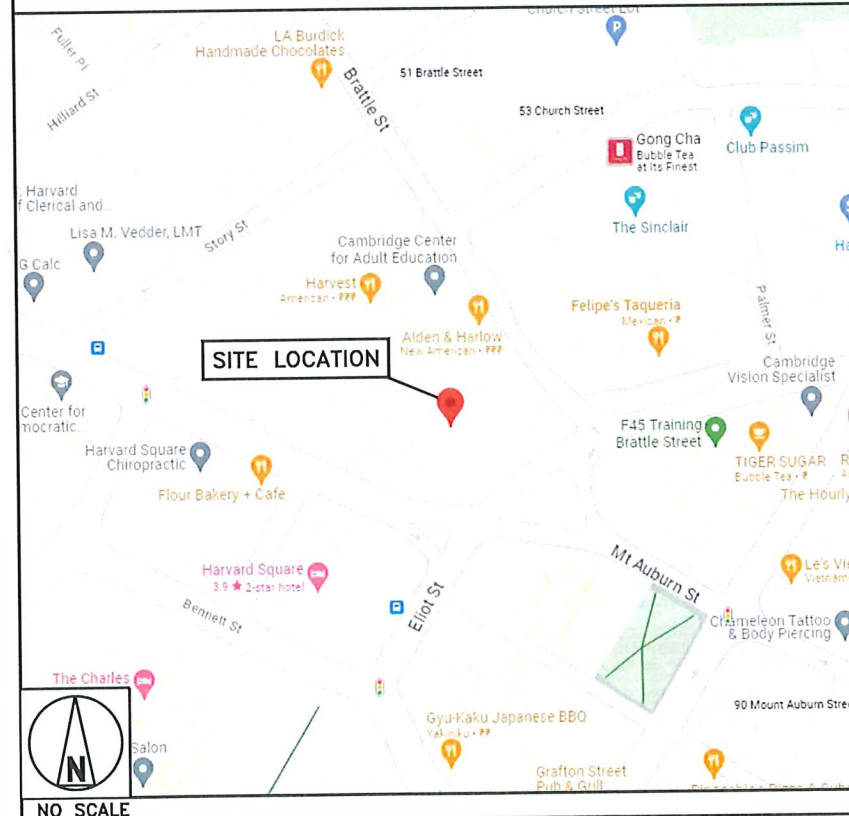

5701 SOUTH SANTA FE DRIVE
LITTLETON, CO 80120



NB+C ENGINEERING SERVICES, LLC.

300 UNICORN PARK DRIVE
SUITE 0501
WOBURN, MA 01801
(978) 856-8308



IT IS A VIOLATION OF LAW FOR ANY PERSON, UNLESS THEY ARE ACTING UNDER THE DIRECTION OF A LICENSED PROFESSIONAL ENGINEER, TO ALTER THIS DOCUMENT.

DRAWN BY: CHECKED BY: APPROVED BY:

CWE NSB DRG

RFDS REV #: 0

CONSTRUCTION DOCUMENTS

SUBMITTALS

REV	DATE	DESCRIPTION
0	01/11/24	ISSUED FOR CONSTRUCTION
1	08/07/24	REVISED UTILITY ROUTING
2	03/14/25	REVISED PER COMMENTS

A&E PROJECT NUMBER

100753

DISH Wireless L.L.C.
PROJECT INFORMATION
BOBOS00341B

1 BRATTLE SQUARE
CAMBRIDGE, MA 02138


SHEET TITLE
TITLE SHEET

SHEET NUMBER


T-1

NOTES


1. CONTRACTOR SHALL FIELD VERIFY ALL DIMENSIONS.
2. ANTENNA SPECIFICATIONS REFER TO ANTENNA SCHEDULE AND TO FINAL CONSTRUCTION RFDS FOR ALL RF DETAILS
3. EXISTING EQUIPMENT OMITTED FOR CLARITY.
4. CONTRACTOR SHALL PAINT ALL DISH WIRELESS, LLC. ANTENNAS AND RELATED APPURTENANCES TO MATCH EXISTING SURROUNDINGS.

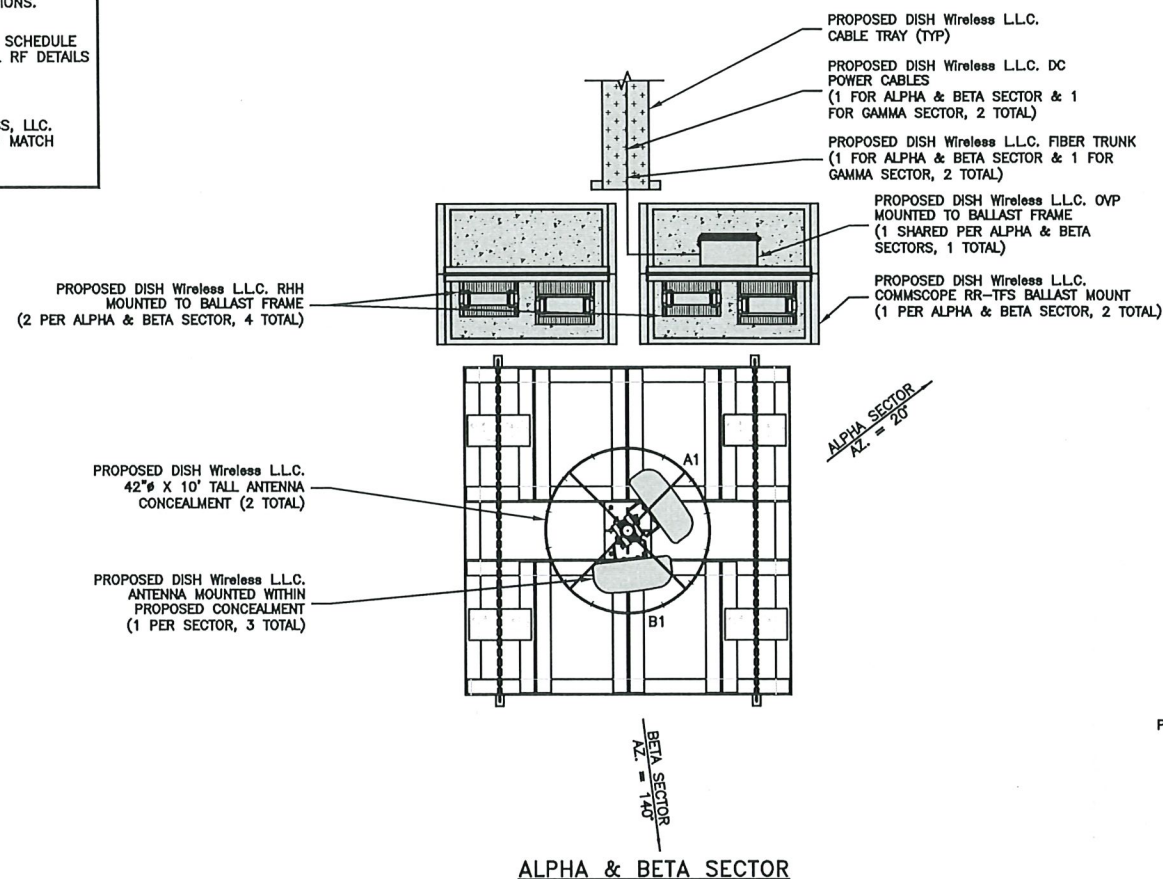


ANTENNA PLAN

 

1

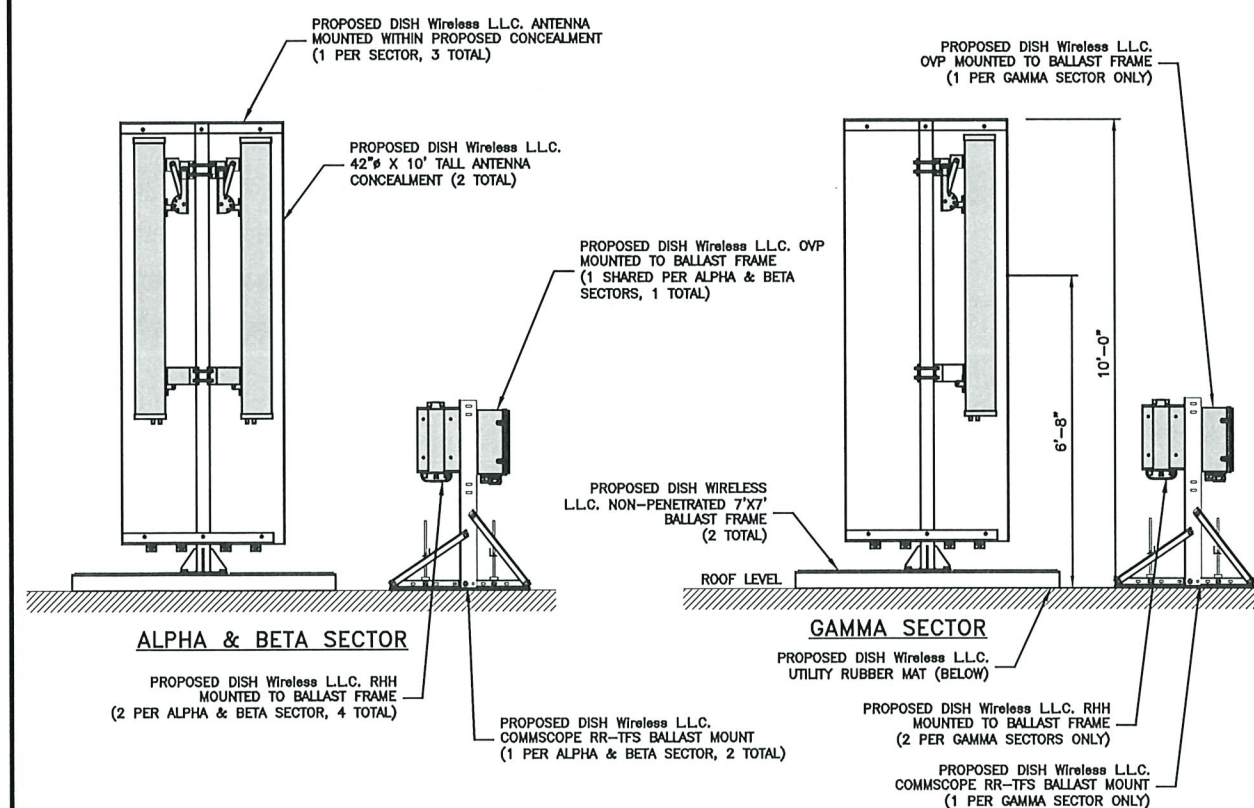

ANTENNA ELEVATION

 

2

SECTOR POS.	ANTENNA					TRANSMISSION CABLE		RRH		OVP
	EXISTING OR PROPOSED	MANUFACTURER - MODEL NUMBER	TECH	AZIMUTH	RAD CENTER	FEED LINE TYPE AND LENGTH	MANUFACTURER - MODEL NUMBER	TECH	POS.	MANUFACTURER MODEL
A1	PROPOSED	JMA - MX08FR0665-21	5G	20°	97'-0"	(1) 4AWG DC POWER CABLE (1) FIBER TRUNK (LENGTH: 200'±)	SAMSUNG - MID BAND SFG-ARR3KM01DI/RF4451D-70A	5G	A1	RAYCAP RDIC-9181-PF-48
A2	---	---	---	---	---		SAMSUNG - LOW BAND SFG-ARR3J601DI/RF4450T-71A	5G	A1	
A3	---	---	---	---	---		---	---	---	
B1	PROPOSED	JMA - MX08FR0665-21	5G	140°	97'-0"	SHARED WITH ALPHA	SAMSUNG - MID BAND SFG-ARR3KM01DI/RF4451D-70A	5G	B1	SHARED WITH ALPHA
B2	---	---	---	---	---		SAMSUNG - LOW BAND SFG-ARR3J601DI/RF4450T-71A	5G	B1	
B3	---	---	---	---	---		---	---	---	
C1	PROPOSED	JMA - MX08FR0665-21	5G	260°	97'-0"	(1) 6AWG DC POWER CABLE (1) FIBER TRUNK (LENGTH: 160'±)	SAMSUNG - MID BAND SFG-ARR3KM01DI/RF4451D-70A	5G	C1	RAYCAP RDIC-3045-PF-48
C2	---	---	---	---	---		SAMSUNG - LOW BAND SFG-ARR3J601DI/RF4450T-71A	5G	C1	
C3	---	---	---	---	---		---	---	---	

NOTES

1. CONTRACTOR TO REFER TO FINAL CONSTRUCTION RFDS FOR ALL RF DETAILS.
2. ANTENNA AND RRH MODELS MAY CHANGE DUE TO EQUIPMENT AVAILABILITY. ALL EQUIPMENT CHANGES MUST BE APPROVED AND REMAIN IN COMPLIANCE WITH THE PROPOSED DESIGN AND STRUCTURAL ANALYSES.

ANTENNA SCHEDULE

NO SCALE

3

dish
wireless.

5701 SOUTH SANTA FE DRIVE
LITTLETON, CO 80120

NB+C
TOTALLY COMMITTED.

NB+C ENGINEERING SERVICES, LLC.

300 UNICORN PARK DRIVE
SUITE 0501
WOBURN, MA 01801
(978) 856-8308



IT IS A VIOLATION OF LAW FOR ANY PERSON, UNLESS THEY ARE ACTING UNDER THE DIRECTION OF A LICENSED PROFESSIONAL ENGINEER, TO ALTER THIS DOCUMENT.

DRAWN BY: CHECKED BY: APPROVED BY:

CWE NSB DRG

RFDS REV #: 0

CONSTRUCTION DOCUMENTS

SUBMITTALS

REV	DATE	DESCRIPTION
0	01/11/24	ISSUED FOR CONSTRUCTION
1	08/07/24	REVISED UTILITY ROUTING
2	03/14/25	REVISED PER COMMENTS

A&E PROJECT NUMBER

100753

DISH Wireless L.L.C.
PROJECT INFORMATION
BOBOS00341B

1 BRATTLE SQUARE
CAMBRIDGE, MA 02138

SHEET TITLE
ANTENNA PLAN,
ELEVATION AND SCHEDULE

SHEET NUMBER

A-2



5701 SOUTH SANTA FE DRIVE
LITTLETON, CO 80120



NB+C ENGINEERING SERVICES, LLC.

300 UNICORN PARK DRIVE
SUITE 0501
WOBBURN, MA 01801
(978) 856-8308



IT IS A VIOLATION OF LAW FOR ANY PERSON,
UNLESS THEY ARE ACTING UNDER THE DIRECTION
OF A LICENSED PROFESSIONAL ENGINEER,
TO ALTER THIS DOCUMENT.

DRAWN BY: CHECKED BY: APPROVED BY:

CWE NSB DRG

RFDS REV #:

CONSTRUCTION DOCUMENTS

SUBMITTALS

REV DATE DESCRIPTION

0	01/11/24	ISSUED FOR CONSTRUCTION
1	08/07/24	REVISED UTILITY ROUTING
2	05/14/25	REVISED PER COMMENTS

A&E PROJECT NUMBER

100753

DISH Wireless L.L.C.
PROJECT INFORMATION

BOBOS00341B

1 BRATTLE SQUARE
CAMBRIDGE, MA 02138

SHEET TITLE

BUILDING
ELEVATION

SHEET NUMBER

A-3

1. CONTRACTOR SHALL FIELD VERIFY ALL DIMENSIONS.
2. CONTRACTOR SHALL MAINTAIN A 10'-0" MINIMUM SEPARATION BETWEEN THE PROPOSED GPS UNIT, TRANSMITTING ANTENNAS AND EXISTING GPS UNITS.
3. CONTRACTOR SHALL PAINT ALL DISH WIRELESS L.L.C. ANTENNAS AND RELATED APPURTENANCES TO MATCH EXISTING SURROUNDINGS.

NOTES

PROPOSED DISH Wireless L.L.C. DOG HOUSE ON TOP OF EXISTING VERTICAL COAX CHASE

PROPOSED DISH Wireless L.L.C. GPS MOUNTED TO PROPOSED DOG HOUSE

EXISTING RHH BALLAST MOUNT BY OTHERS (TYP)

EXISTING ANTENNA FACADE MOUNTED BY OTHERS (TYP)

EXISTING VENT (TYP)

PROPOSED DISH Wireless L.L.C. RHH MOUNTED TO BALLAST FRAME (2 PER ALPHA & BETA SECTORS ONLY)

PROPOSED DISH Wireless L.L.C. RHH MOUNTED TO BALLAST FRAME (1 PER ALPHA & BETA SECTORS ONLY)

PROPOSED DISH Wireless L.L.C. RHH MOUNTED TO BALLAST FRAME (1 PER ALPHA & BETA SECTORS, 1 TOTAL) (BEHIND)


PROPOSED DISH Wireless L.L.C. OVP MOUNTED TO BALLAST FRAME (1 SHARED PER ALPHA & BETA SECTORS, 1 TOTAL) (BEHIND)

PROPOSED DISH Wireless L.L.C. CONCEALMENT (2 TOTAL)


PROPOSED DISH Wireless L.L.C. ANTENNA MOUNTED WITHIN PROPOSED CONCEALMENT (1 PER SECTOR, 3 TOTAL)

PROPOSED DISH Wireless L.L.C. RHH MOUNTED TO BALLAST FRAME (2 PER ALPHA & BETA SECTORS, TOTAL OF 4) (BEHIND)


PROPOSED DISH Wireless L.L.C. POWER AND FIBER CABLES FROM EXISTING EQUIPMENT ROOM ON 1ST FLOOR, THROUGH 1ST FLOOR HALLWAY TO EXISTING FLOOR, THEN UP PENETRATION TO 2ND FLOOR JANITOR'S CLOSET, THEN UP EXISTING CHASE FROM 2ND FLOOR LOBBY TO 6TH FLOOR LOBBY THROUGH EXISTING PENTHOUSE FLOOR PENETRATIONS AND ROOF PENETRATIONS TO PROPOSED DOG HOUSE.

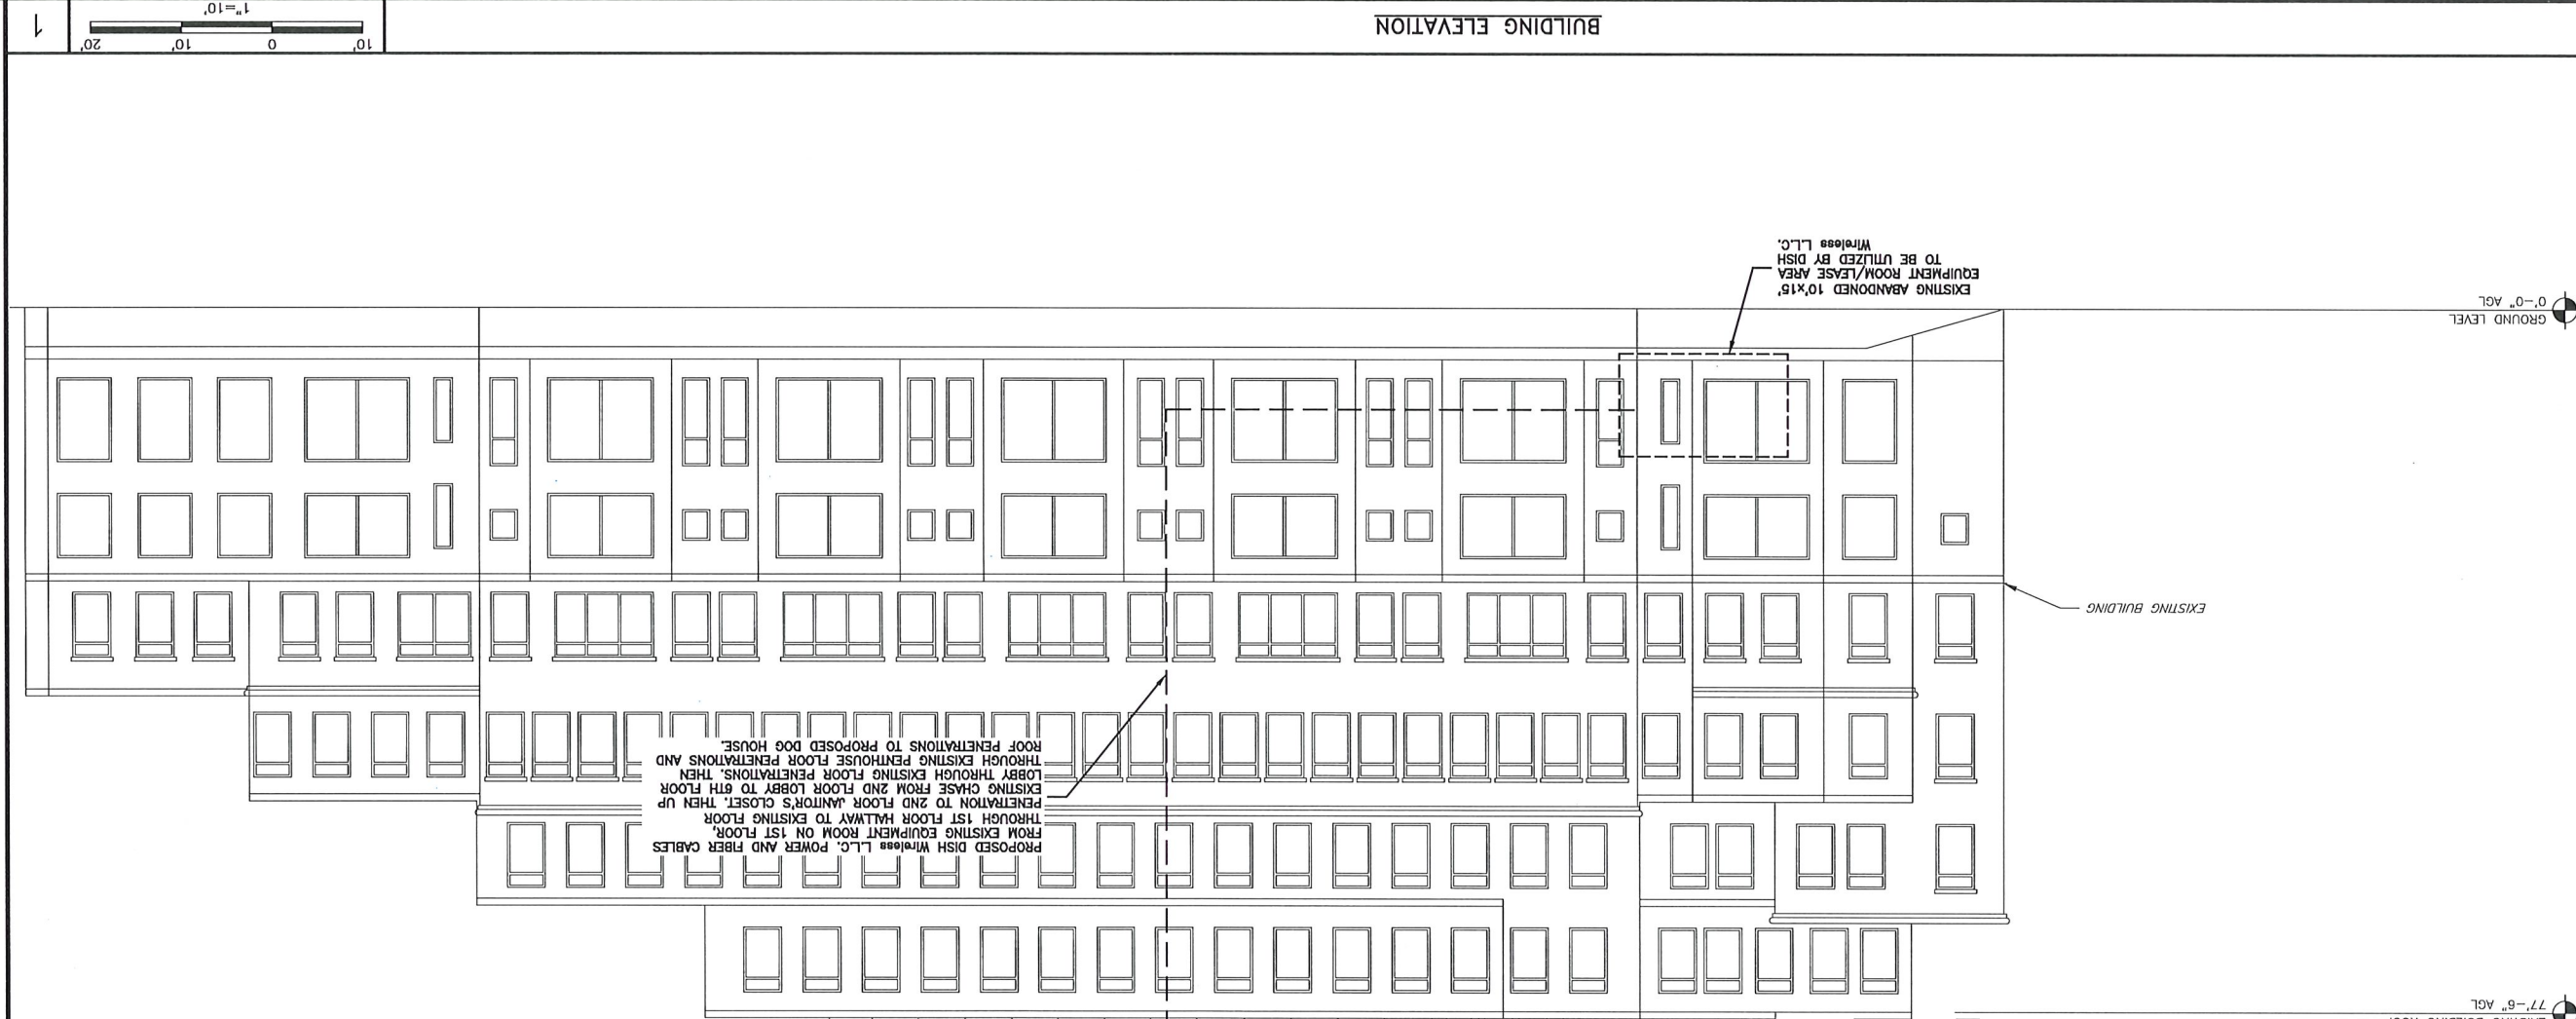

- TOP OF PROPOSED HIGHEST APPURTENANCE
- 100'-4" AGL
- 100'-0" AGL
- TOP OF PROPOSED DISH Wireless L.L.C. ANTENNA (TYP 1 PER SECTOR, 3 TOTAL)
- EXISTING HIGHEST APPURTENANCE
- 97'-4" AGL
- PROPOSED DISH Wireless L.L.C. ANTENNA (TYP 1 PER SECTOR, 3 TOTAL) RAD CENTER @ 97'-0" AGL
- EXISTING PENTHOUSE ROOF
- 90'-4" AGL
- EXISTING EMPTY EQUIPMENT SHELTER ROOF
- 87'-6" AGL
- EXISTING BUILDING PARAPET
- 78'-3" AGL
- EXISTING BUILDING ROOF
- 77'-6" AGL

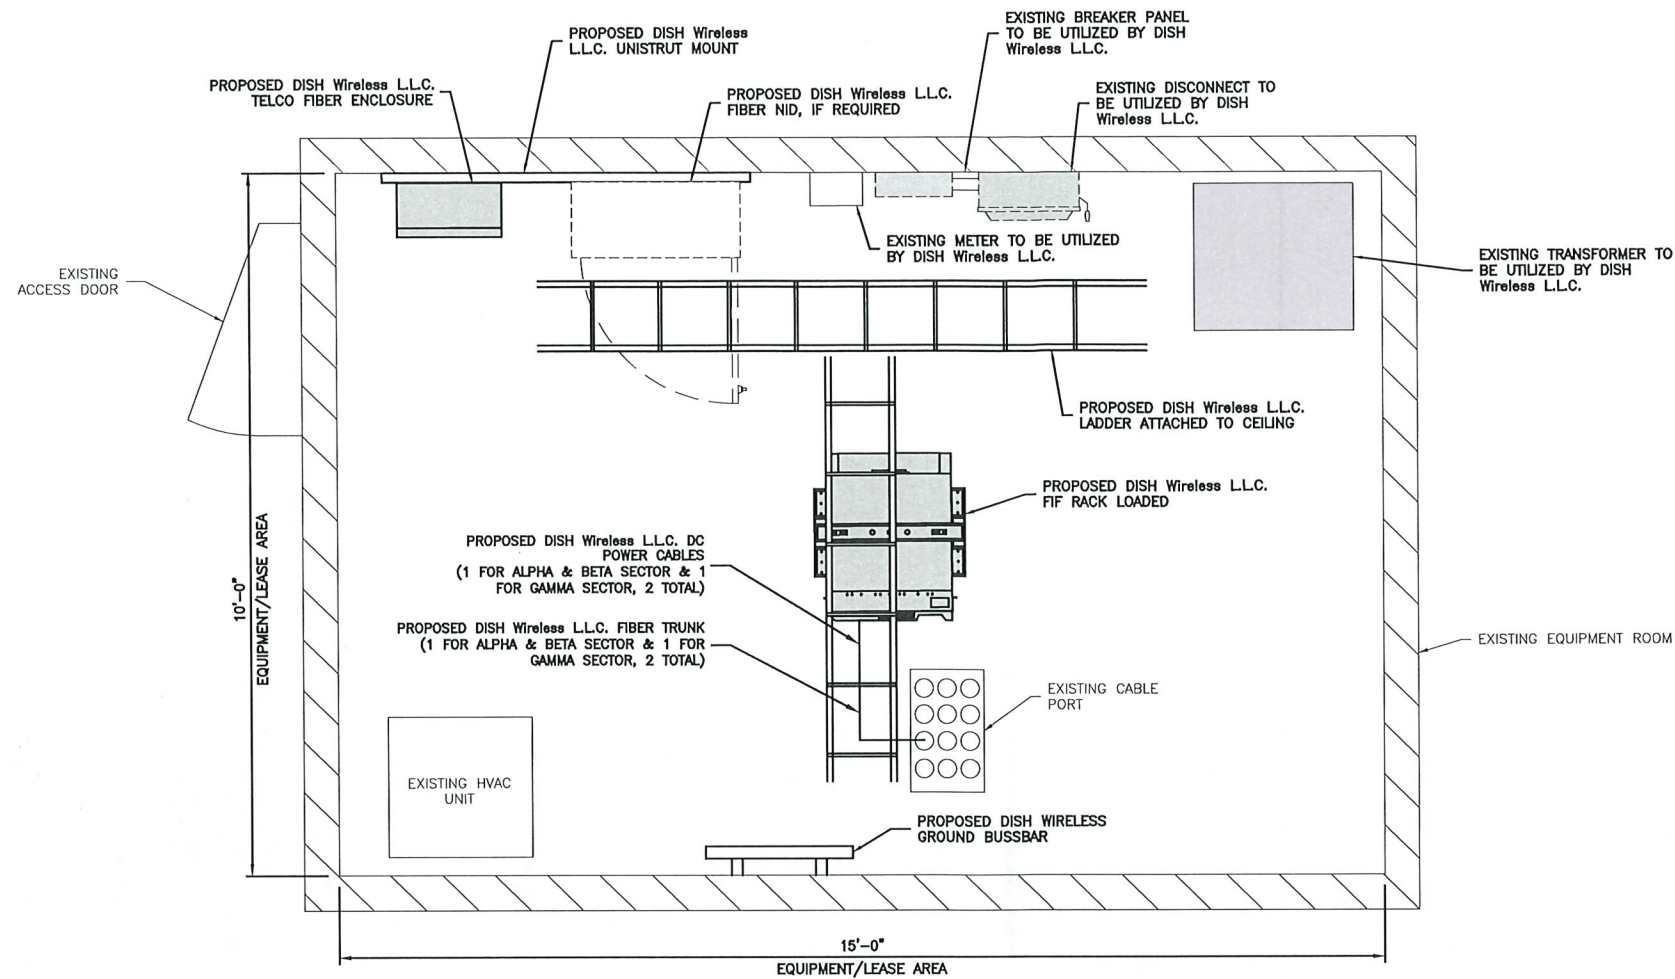


EQUIPMENT ROOM PLAN

 


1

NOTE

1. FIF RACK OMITTED FOR CLARITY

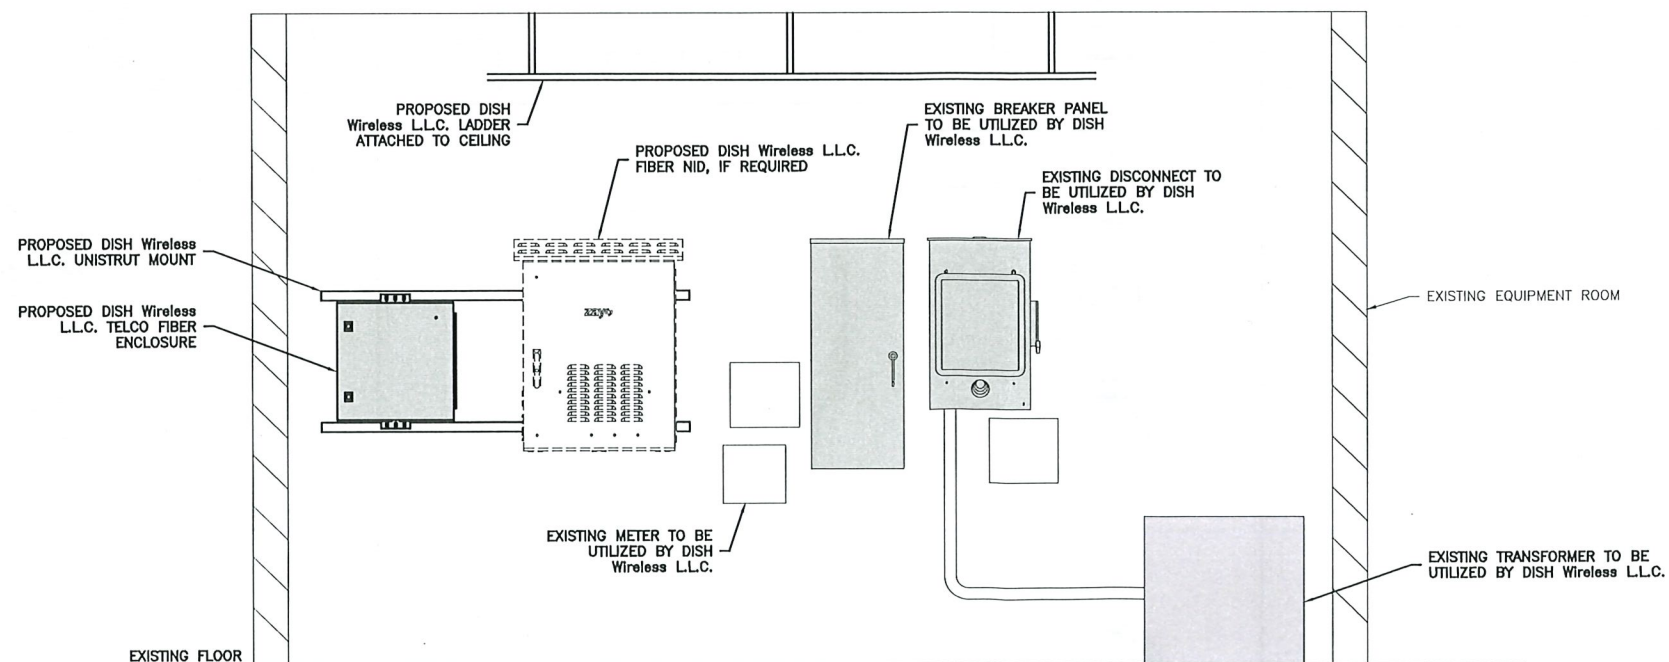

EQUIPMENT ROOM ELEVATION

 

2

dish
wireless.

5701 SOUTH SANTA FE DRIVE
LITTLETON, CO 80120

NB+C
TOTALLY COMMITTED.

NB+C ENGINEERING SERVICES, LLC.

300 UNICORN PARK DRIVE
SUITE 0501
WOBURN, MA 01801
(978) 856-8308



IT IS A VIOLATION OF LAW FOR ANY PERSON,
UNLESS THEY ARE ACTING UNDER THE DIRECTION
OF A LICENSED PROFESSIONAL ENGINEER,
TO ALTER THIS DOCUMENT.

DRAWN BY: CHECKED BY: APPROVED BY:

CWE NSB DRG

RFDS REV #: 0

CONSTRUCTION
DOCUMENTS

SUBMITTALS

REV	DATE	DESCRIPTION
0	01/11/24	ISSUED FOR CONSTRUCTION
1	08/07/24	REVISED UTILITY ROUTING
2	03/14/25	REVISED PER COMMENTS

A&E PROJECT NUMBER

100753

DISH Wireless L.L.C.
PROJECT INFORMATION

BOBOS00341B

1 BRATTLE SQUARE
CAMBRIDGE, MA 02138

SHEET TITLE
EQUIPMENT PLATFORM AND
H-FRAME DETAILS

SHEET NUMBER

A-4



5701 SOUTH SANTA FE DRIVE
LITTLETON, CO 80120



TOTALLY COMMITTED.

300 UNICORN PARK DRIVE
SUITE 0501
WOBBURN, MA 01801
(978) 856-8308



IT IS A VIOLATION OF LAW FOR ANY PERSON,
UNLESS THEY ARE ACTING UNDER THE DIRECTION
OF A LICENSED PROFESSIONAL ENGINEER,
TO ALTER THIS DOCUMENT.

DRAWN BY: CHECKED BY: APPROVED BY:

CWE NSB DRG

RFD REV #:

CONSTRUCTION DOCUMENTS

SUBMITTALS

REV DATE DESCRIPTION

0	01/11/24	ISSUED FOR CONSTRUCTION
1	08/07/24	REVISED UTILITY ROUTING
2	03/14/25	REVISED PER COMMENTS

A&E PROJECT NUMBER

100753

DISH Wireless L.L.C.
PROJECT INFORMATION

BOBOS00341B

1 BRATTLE SQUARE
CAMBRIDGE, MA 02138

SHEET TITLE


ELECTRICAL/FIBER ROUTE
PLAN AND NOTES

SHEET NUMBER


E-1

1. UTILIZE EXISTING ABANDONED CONDUITS WHERE AVAILABLE. REPLACE/INSTALL NEW CONDUIT SECTIONS AS NEEDED.
2. CONTRACTOR TO VERIFY WITH DISH Wireless L.L.C. THE LOCATION OF THE POWER AND FIBER SOURCE PRIOR TO CONSTRUCTION.
3. CONTRACTOR SHALL FIELD VERIFY ALL DIMENSIONS.

NOTES


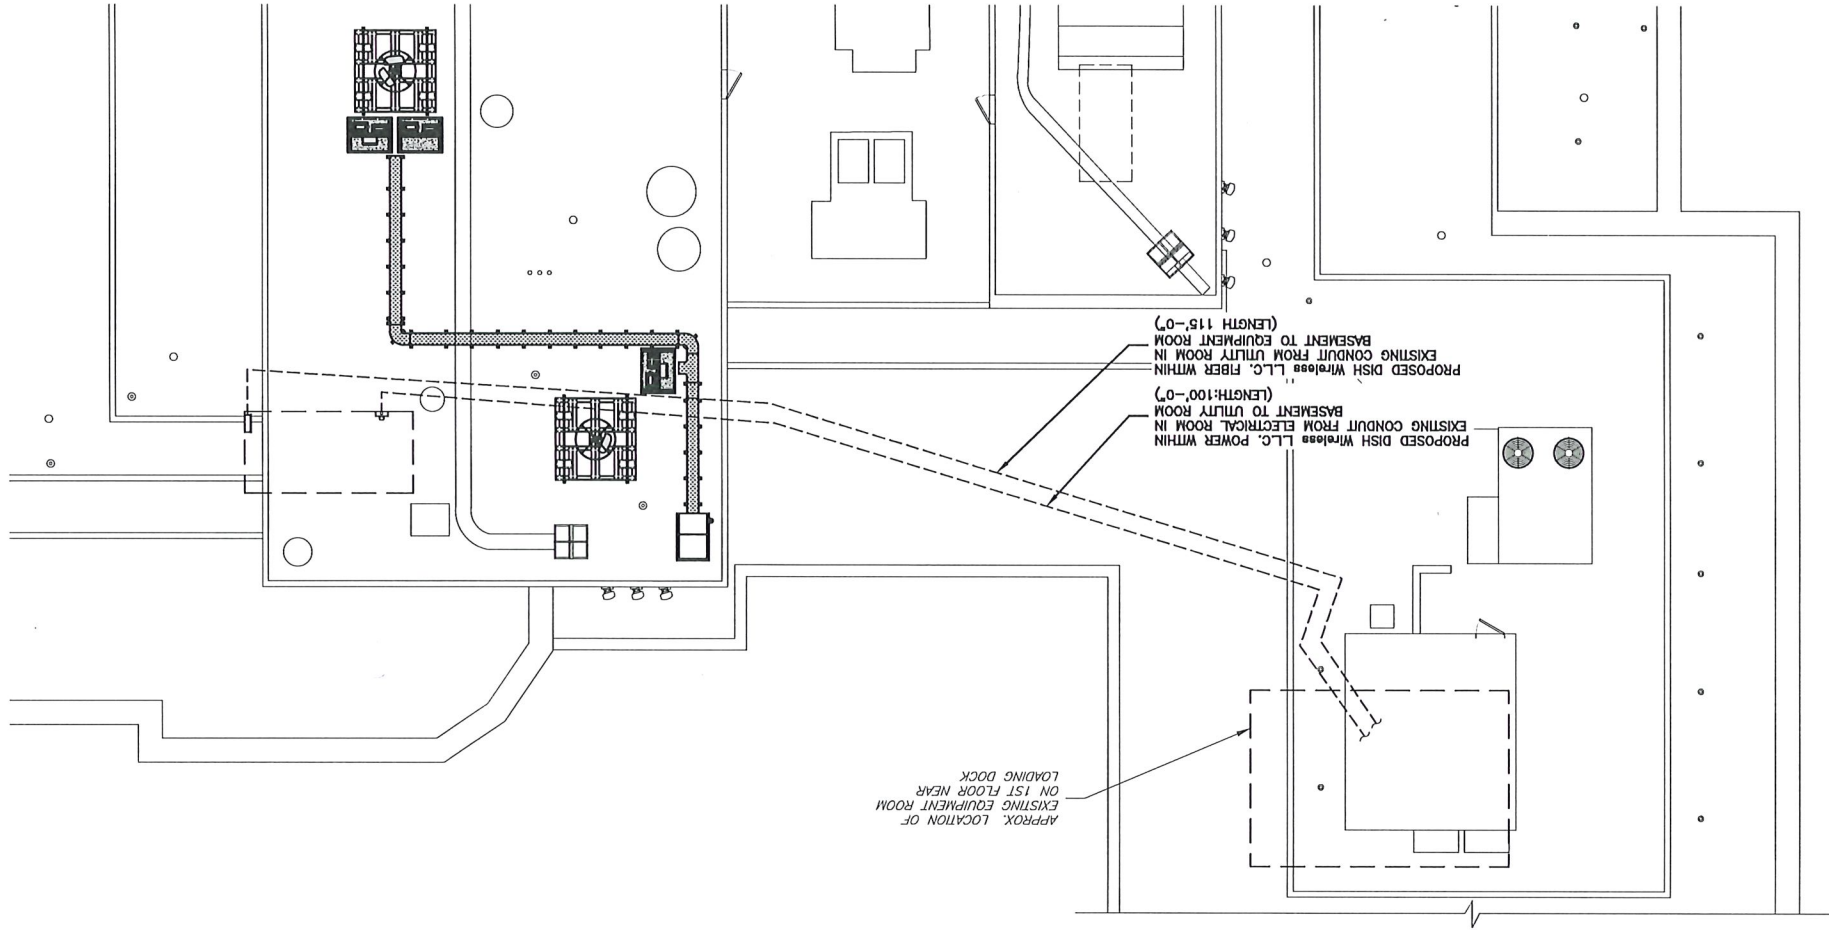


UTILITY ROUTE PLAN

 


1

 UTILITY ROUTE ELEVATION

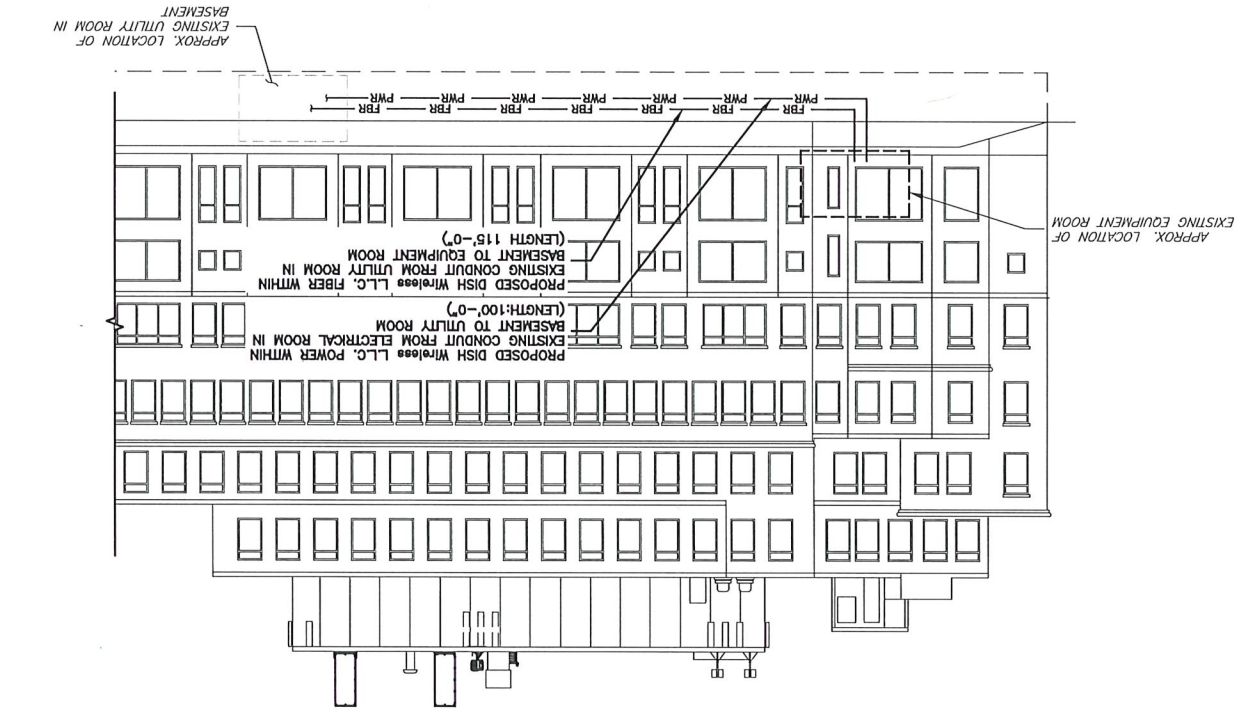


2

 UTILITY ROOM



3

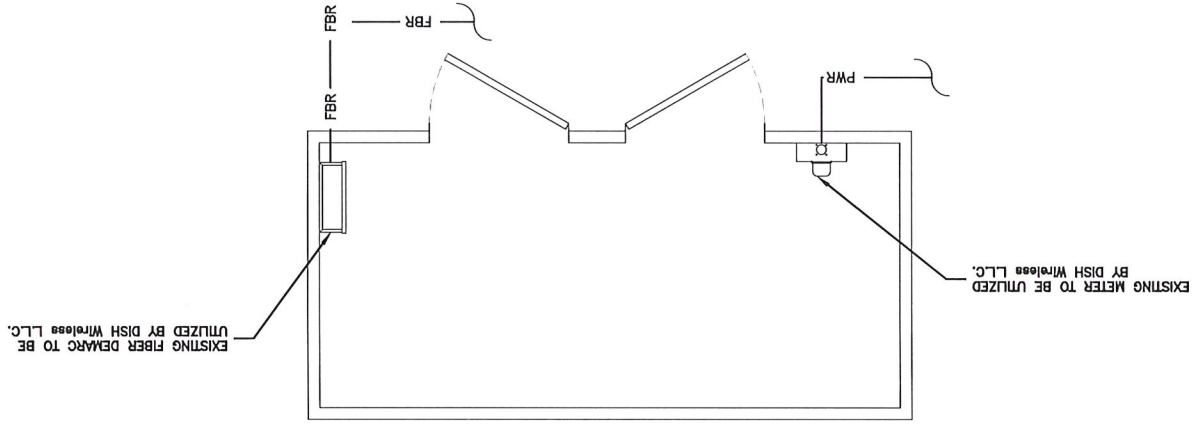

DC POWER WIRING SHALL BE COLOR CODED AT EACH END FOR IDENTIFYING +24V AND -48V CONDUCTORS. RED MARKINGS SHALL IDENTIFY +24V AND BLUE MARKINGS SHALL IDENTIFY -48V.

1. CONTRACTOR SHALL INSPECT THE EXISTING CONDITIONS PRIOR TO SUBMITTING A BID. ANY QUESTIONS ARISING DURING THE BID PERIOD IN REGARDS TO THE CONTRACTOR'S FUNCTIONS, THE SCOPE OF WORK, OR ANY OTHER ISSUE RELATED TO THIS PROJECT SHALL BE BROUGHT UP DURING THE BID PERIOD WITH THE PROJECT MANAGER FOR CLARIFICATION, NOT AFTER THE CONTRACT HAS BEEN AWARDED.

2. ALL ELECTRICAL WORK SHALL BE DONE IN ACCORDANCE WITH CURRENT NATIONAL ELECTRICAL CODES AND ALL STATE AND LOCAL CODES, LAWS, AND ORDINANCES. PROVIDE ALL COMPONENTS AND WIRING SIZES AS REQUIRED TO MEET NEC STANDARDS.

3. LOCATION OF EQUIPMENT, CONDUIT AND DEVICES SHOWN ON THE DRAWINGS ARE APPROXIMATE AND SHALL BE COORDINATED WITH FIELD CONDITIONS PRIOR TO CONSTRUCTION.

4. CONDUIT ROUGH-IN SHALL BE COORDINATED WITH THE MECHANICAL EQUIPMENT TO AVOID LOCATION CONFLICTS. VERIFY WITH THE MECHANICAL EQUIPMENT CONTRACTOR AND COMPLY AS REQUIRED.

5. CONTRACTOR SHALL PROVIDE ALL BREAKERS, CONDUITS AND CIRCUITS AS REQUIRED FOR A COMPLETE SYSTEM.

6. CONTRACTOR SHALL PROVIDE PULL BOXES AND JUNCTION BOXES AS REQUIRED BY THE NEC ARTICLE 314.

7. CONTRACTOR SHALL PROVIDE ALL STRAIN RELIEF AND CABLE SUPPORTS FOR ALL CABLE ASSEMBLIES. INSTALLATION SHALL BE IN ACCORDANCE WITH MANUFACTURER'S SPECIFICATIONS AND RECOMMENDATIONS.

8. ALL DISCONNECTS AND CONTROLLING DEVICES SHALL BE PROVIDED WITH ENGRAVED PHENOLIC NAMEPLATES INDICATING EQUIPMENT CONTROLLED, BRANCH CIRCUITS INSTALLED ON, AND PANEL FIELD LOCATIONS FED FROM.

9. INSTALL AN EQUIPMENT GROUNDING CONDUCTOR IN ALL CONDUITS PER THE SPECIFICATIONS AND NEC 250. THE EQUIPMENT GROUNDING CONDUCTORS SHALL BE BONDED AT ALL JUNCTION BOXES, PULL BOXES, AND ALL DISCONNECT SWITCHES, AND EQUIPMENT CABINETS.

10. ALL NEW MATERIAL SHALL HAVE A U.L. LABEL.

11. PANEL SCHEDULE LOADING AND CIRCUIT ARRANGEMENTS REFLECT POST-CONSTRUCTION EQUIPMENT.

12. CONTRACTOR SHALL BE RESPONSIBLE FOR AS-BUILT PANEL SCHEDULE AND SITE DRAWINGS.

DARK TELCO BOX – INTERIOR WIRING LAYOUT

NO SCALE

2

CABLE WALL MOUNT SUPPORT

UNISTRUT TYPE	GRAINGER P1000T
UNISTRUT DIMENSIONS (HxWxL)	1 5/8"x 1 5/8"x 12"
WEIGHT/ VOLUME	1.85 LB PER FOOT
ULTIMATE LOAD CAPACITY	718.5 LB

NOTES:
1. ALL HARDWARE AND PARTS SHALL BE HOT DIPPED GALVANIZED WITH LOCK WASHERS AND HEAVY HEX NUTS.
2. VERTICAL CABLE MOUNT: 4'-0" MAX. UNISTRUT SEPARATION
3. HORIZONTAL CABLE MOUNT: 3'-0" MAX UNISTRUT SEPARATION

EXISTING WALL

PLAN

EXISTING WALL

SIDE

CABLE CLAMP OR APPROVED EQUAL
EMT/PVC OR APPROVED EQUAL
CABLE
CABLE SUPPORT STEEL CHANNEL OR APPROVED EQUAL
EXPANSION ANCHOR OR APPROVED EQUAL

CABLE WALL MOUNT SUPPORT DETAIL

NO SCALE

4

LIT TELCO BOX – INTERIOR WIRING LAYOUT (OPTIONAL)

NO SCALE

3

NOT USED

NO SCALE

5

NOT USED

NO SCALE

6

NOT USED

NO SCALE

7

NOT USED

NO SCALE

8

dish

wireless.

5701 SOUTH SANTA FE DRIVE
LITTLETON, CO 80120

NB+C

TOTALLY COMMITTED.

NB+C ENGINEERING SERVICES, LLC.

300 UNICORN PARK DRIVE
SUITE 0501
WOBURN, MA 01801
(978) 856-8308

COMMONWEALTH OF MASSACHUSETTS

REGISTERED PROFESSIONAL ENGINEER

NO. 50019

IT IS A VIOLATION OF LAW FOR ANY PERSON, UNLESS THEY ARE ACTING UNDER THE DIRECTION OF A LICENSED PROFESSIONAL ENGINEER, TO ALTER THIS DOCUMENT.

DRAWN BY: CWB

CHECKED BY: NSB

APPROVED BY: DRG

RFDS REV #: 0

CONSTRUCTION DOCUMENTS

SUBMITTALS

REV	DATE	DESCRIPTION
0	01/11/24	ISSUED FOR CONSTRUCTION
1	08/07/24	REVISED UTILITY ROUTING
2	03/14/25	REVISED PER COMMENTS


A&E PROJECT NUMBER
100753

DISH Wireless L.L.C.
PROJECT INFORMATION
BOBOS00341B
1 BRATTLE SQUARE
CAMBRIDGE, MA 02138


SHEET TITLE
ELECTRICAL
DETAILS

SHEET NUMBER
E-2

PROPOSED CHARLES PANEL SCHEDULE									
LOAD SERVED	VOLT AMPS		TRIP	CT	PHASE	#	TRIP	VOLT AMPS	
	L1	L2						L1	L2
PPC GFCI OUTLET	180	180	15A	1	A	2	30A	2880	2880
CHARLES GFCI OUTLET	180	180	15A	3	B	4	30A	2880	2880
ABB/GE INFINITY RECEPTER 1				5	A	6	30A	2880	2880
ABB/GE INFINITY RECEPTER 2				7	B	8	30A	2880	2880
ABB/GE INFINITY RECEPTER 3				9	A	10	30A	2880	2880
ABB/GE INFINITY RECEPTER 4				11	B	12	30A	2880	2880
ABB/GE INFINITY RECEPTER 5				13	A	14	30A	2880	2880
ABB/GE INFINITY RECEPTER 6				15	B	16	30A	2880	2880
ABB/GE INFINITY RECEPTER 7				17	A	18	30A	2880	2880
ABB/GE INFINITY RECEPTER 8				19	B	20	30A	2880	2880
ABB/GE INFINITY RECEPTER 9				21	A	22	30A	2880	2880
ABB/GE INFINITY RECEPTER 10				23	B	24	30A	2880	2880
ABB/GE INFINITY RECEPTER 11				25	A	26	30A	2880	2880
ABB/GE INFINITY RECEPTER 12				27	B	28	30A	2880	2880
ABB/GE INFINITY RECEPTER 13				29	A	30	30A	2880	2880
ABB/GE INFINITY RECEPTER 14				31	B	32	30A	2880	2880
ABB/GE INFINITY RECEPTER 15				33	A	34	30A	2880	2880
ABB/GE INFINITY RECEPTER 16				35	B	36	30A	2880	2880
ABB/GE INFINITY RECEPTER 17				37	A	38	30A	2880	2880
ABB/GE INFINITY RECEPTER 18				39	B	40	30A	2880	2880
ABB/GE INFINITY RECEPTER 19				41	A	42	30A	2880	2880
ABB/GE INFINITY RECEPTER 20				43	B	44	30A	2880	2880
ABB/GE INFINITY RECEPTER 21				45	A	46	30A	2880	2880
ABB/GE INFINITY RECEPTER 22				47	B	48	30A	2880	2880
ABB/GE INFINITY RECEPTER 23				49	A	50	30A	2880	2880
ABB/GE INFINITY RECEPTER 24				51	B	52	30A	2880	2880
ABB/GE INFINITY RECEPTER 25				53	A	54	30A	2880	2880
ABB/GE INFINITY RECEPTER 26				55	B	56	30A	2880	2880
ABB/GE INFINITY RECEPTER 27				57	A	58	30A	2880	2880
ABB/GE INFINITY RECEPTER 28				59	B	60	30A	2880	2880
ABB/GE INFINITY RECEPTER 29				61	A	62	30A	2880	2880
ABB/GE INFINITY RECEPTER 30				63	B	64	30A	2880	2880
ABB/GE INFINITY RECEPTER 31				65	A	66	30A	2880	2880
ABB/GE INFINITY RECEPTER 32				67	B	68	30A	2880	2880
ABB/GE INFINITY RECEPTER 33				69	A	70	30A	2880	2880
ABB/GE INFINITY RECEPTER 34				71	B	72	30A	2880	2880
ABB/GE INFINITY RECEPTER 35				73	A	74	30A	2880	2880
ABB/GE INFINITY RECEPTER 36				75	B	76	30A	2880	2880
ABB/GE INFINITY RECEPTER 37				77	A	78	30A	2880	2880
ABB/GE INFINITY RECEPTER 38				79	B	80	30A	2880	2880
ABB/GE INFINITY RECEPTER 39				81	A	82	30A	2880	2880
ABB/GE INFINITY RECEPTER 40				83	B	84	30A	2880	2880
ABB/GE INFINITY RECEPTER 41				85	A	86	30A	2880	2880
ABB/GE INFINITY RECEPTER 42				87	B	88	30A	2880	2880
ABB/GE INFINITY RECEPTER 43				89	A	90	30A	2880	2880
ABB/GE INFINITY RECEPTER 44				91	B	92	30A	2880	2880
ABB/GE INFINITY RECEPTER 45				93	A	94	30A	2880	2880
ABB/GE INFINITY RECEPTER 46				95	B	96	30A	2880	2880
ABB/GE INFINITY RECEPTER 47				97	A	98	30A	2880	2880
ABB/GE INFINITY RECEPTER 48				99	B	100	30A	2880	2880
ABB/GE INFINITY RECEPTER 49				101	A	102	30A	2880	2880
ABB/GE INFINITY RECEPTER 50				103	B	104	30A	2880	2880
ABB/GE INFINITY RECEPTER 51				105	A	106	30A	2880	2880
ABB/GE INFINITY RECEPTER 52				107	B	108	30A	2880	2880
ABB/GE INFINITY RECEPTER 53				109	A	110	30A	2880	2880
ABB/GE INFINITY RECEPTER 54				111	B	112	30A	2880	2880
ABB/GE INFINITY RECEPTER 55				113	A	114	30A	2880	2880
ABB/GE INFINITY RECEPTER 56				115	B	116	30A	2880	2880
ABB/GE INFINITY RECEPTER 57				117	A	118	30A	2880	2880
ABB/GE INFINITY RECEPTER 58				119	B	120	30A	2880	2880
ABB/GE INFINITY RECEPTER 59				121	A	122	30A	2880	2880
ABB/GE INFINITY RECEPTER 60				123	B	124	30A	2880	2880
ABB/GE INFINITY RECEPTER 61				125	A	126	30A	2880	2880
ABB/GE INFINITY RECEPTER 62				127	B	128	30A	2880	2880
ABB/GE INFINITY RECEPTER 63				129	A	130	30A	2880	2880
ABB/GE INFINITY RECEPTER 64				131	B	132	30A	2880	2880
ABB/GE INFINITY RECEPTER 65				133	A	134	30A	2880	2880
ABB/GE INFINITY RECEPTER 66				135	B	136	30A	2880	2880
ABB/GE INFINITY RECEPTER 67				137	A	138	30A	2880	2880
ABB/GE INFINITY RECEPTER 68				139	B	140	30A	2880	2880
ABB/GE INFINITY RECEPTER 69				141	A	142	30A	2880	2880
ABB/GE INFINITY RECEPTER 70				143	B	144	30A	2880	2880
ABB/GE INFINITY RECEPTER 71				145	A	146	30A	2880	2880
ABB/GE INFINITY RECEPTER 72				147	B	148	30A	2880	2880
ABB/GE INFINITY RECEPTER 73				149	A	150	30A	2880	2880
ABB/GE INFINITY RECEPTER 74				151	B	152	30A	2880	2880
ABB/GE INFINITY RECEPTER 75				153	A	154	30A	2880	2880
ABB/GE INFINITY RECEPTER 76				155	B	156	30A	2880	2880
ABB/GE INFINITY RECEPTER 77				157	A	158	30A	2880	2880
ABB/GE INFINITY RECEPTER 78				159	B	160	30A	2880	2880
ABB/GE INFINITY RECEPTER 79				161	A	162	30A	2880	2880
ABB/GE INFINITY RECEPTER 80				163	B	164	30A	2880	2880
ABB/GE INFINITY RECEPTER 81				165	A	166	30A	2880	2880
ABB/GE INFINITY RECEPTER 82				167	B	168	30A	2880	2880
ABB/GE INFINITY RECEPTER 83				169	A	170	30A	2880	2880
ABB/GE INFINITY RECEPTER 84				171	B	172	30A	2880	2880
ABB/GE INFINITY RECEPTER 85				173	A	174	30A	2880	2880
ABB/GE INFINITY RECEPTER 86				175	B	176	30A	2880	2880
ABB/GE INFINITY RECEPTER 87				177	A	178	30A	2880	2880
ABB/GE INFINITY RECEPTER 88				179	B	180	30A	2880	2880
ABB/GE INFINITY RECEPTER 89				181	A	182	30A	2880	2880
ABB/GE INFINITY RECEPTER 90				183	B	184	30A	2880	2880
ABB/GE INFINITY RECEPTER 91				185	A	186	30A	2880	2880
ABB/GE INFINITY RECEPTER 92				187	B	188	30A	2880	2880
ABB/GE INFINITY RECEPTER 93				189	A	190	30A	2880	2880
ABB/GE INFINITY RECEPTER 94				191	B	192	30A	2880	2880
ABB/GE INFINITY RECEPTER 95				193	A	194	30A	2880	2880
ABB/GE INFINITY RECEPTER 96				195	B	196	30A	2880	2880
ABB/GE INFINITY RECEPTER 97				197	A	198	30A	2880	2880
ABB/GE INFINITY RECEPTER 98				199	B	200	30A	2880	2880
ABB/GE INFINITY RECEPTER 99				201	A	202	30A	2880	2880
ABB/GE INFINITY RECEPTER 100				203	B	204	30A	2880	2880
ABB/GE INFINITY RECEPTER 101				205	A	206	30A	2880	2880
ABB/GE INFINITY RECEPTER 102				207	B	208	30A	2880	2880
ABB/GE INFINITY RECEPTER 103				209	A	210	30A	2880	2880
ABB/GE INFINITY RECEPTER 104				211	B	212	30A	2880	2880
ABB/GE INFINITY RECEPTER 105				213	A	214	30A	2880	2880
ABB/GE INFINITY RECEPTER 106				215	B	216	30A	2880	2880
ABB/GE INFINITY RECEPTER 107				217	A	218	30A	2880	2880
ABB/GE INFINITY RECEPTER 108				219	B	220	30A	2880	2880
ABB/GE INFINITY RECEPTER 109				221	A	222	30A	2880	2880
ABB/GE INFINITY RECEPTER 110				223	B	224	30A	2880	2880
ABB/GE INFINITY RECEPTER 111				225	A	226	30A	2880	2880
ABB/GE INFINITY RECEPTER 112				227	B	228	30A	2880	2880
ABB/GE INFINITY RECEPTER 113				229	A	230	30A	2880	2880
ABB/GE INFINITY RECEPTER 114				231	B	232	30A	2880	2880
ABB/GE INFINITY RECEPTER 115				233	A	234	30A	2880	2880
ABB/GE INFINITY RECEPTER 116				235	B	236	30A	2880	2880
ABB/GE INFINITY RECEPTER 117				237	A	238	30A	2880	2880
ABB/GE INFINITY RECEPTER 118				239	B	240	30A	2880	2880
ABB/GE INFINITY RECEPTER 119				241	A	242	30A	2880	2880
ABB/GE INFINITY RECEPTER 120				243	B	244	30A	2880	2880
ABB/GE INFINITY RECEPTER 121				245	A	246	30A	2880	2880
ABB/GE INFINITY RECEPTER 122				247	B	248	30A	2880	2880
ABB/GE INFINITY RECEPTER 123				249	A	250	30A	2880	2880
ABB/GE INFINITY RECEPTER 124				251	B	252	30A	2880	2880
ABB/GE INFINITY RECEPTER 125				253	A	254	30A	2880	2880
ABB/GE INFINITY RECEPTER 126				255	B	256	30A	2880	2880
ABB/GE INFINITY RECEPTER 127				257	A	258	30A	2880	2880
ABB/GE INFINITY RECEPTER 128				259	B	260	30A	2880	2880
ABB/GE INFINITY RECEPTER 129				261	A	262	30A	2880	2880
ABB/GE INFINITY RECEPTER 130				263	B	264	30A	2880	2880
ABB/GE INFINITY RECEPTER 131				265	A	266	30A	2880	2880
ABB/GE INFINITY RECEPTER 132				267	B	268	30A	2880	2880
ABB/GE INFINITY RECEPTER 133				269	A	270	30A	2880	2880
ABB/GE INFINITY RECEPTER 134				271	B	272	30A	2880	2880
ABB/GE INFINITY RECEPTER 135				273	A	274	30A	2880	2880
ABB/GE INFINITY RECEPTER 136				275	B	276	30A	2880	2880
ABB/GE INFINITY RECEPTER 137				277	A	278	30A	2880	2880
ABB/GE INFINITY RECEPTER 138				279	B	280	30A	2880	2880
ABB/GE INFINITY RECEPTER 139				281	A	282	30A	2880	2880
ABB/GE INFINITY RECEPTER 140				283	B	284	30A	2880	2880
ABB/GE INFINITY RECEPTER 141				285	A	286	30A	2880	2880
ABB/GE INFINITY RECEPTER 142				287	B	288	30A	2880	2880
ABB/GE INFINITY RECEPTER 143				289	A	290	30A	2880	2880
ABB/GE INFINITY RECEPTER 144				291	B	292	30A	2880	2880
ABB/GE INFINITY RECEPTER 145				293	A	294	30A	2880	2880
ABB/GE INFINITY RECEPTER 146				295	B	296	30A	2880	2880
ABB/GE INFINITY RECEPTER 147				297	A	298	30A	2880	2880
ABB/GE INFINITY RECEPTER 148				299	B	300	30A	2880	2880
ABB/GE INFINITY RECEPTER 149				301	A	302	30A	2880	2880
ABB/GE INFINITY RECEPTER 150				303	B	304	30A	2880	2880
ABB/GE INFINITY RECEPTER 151				305	A	306	30A	28	

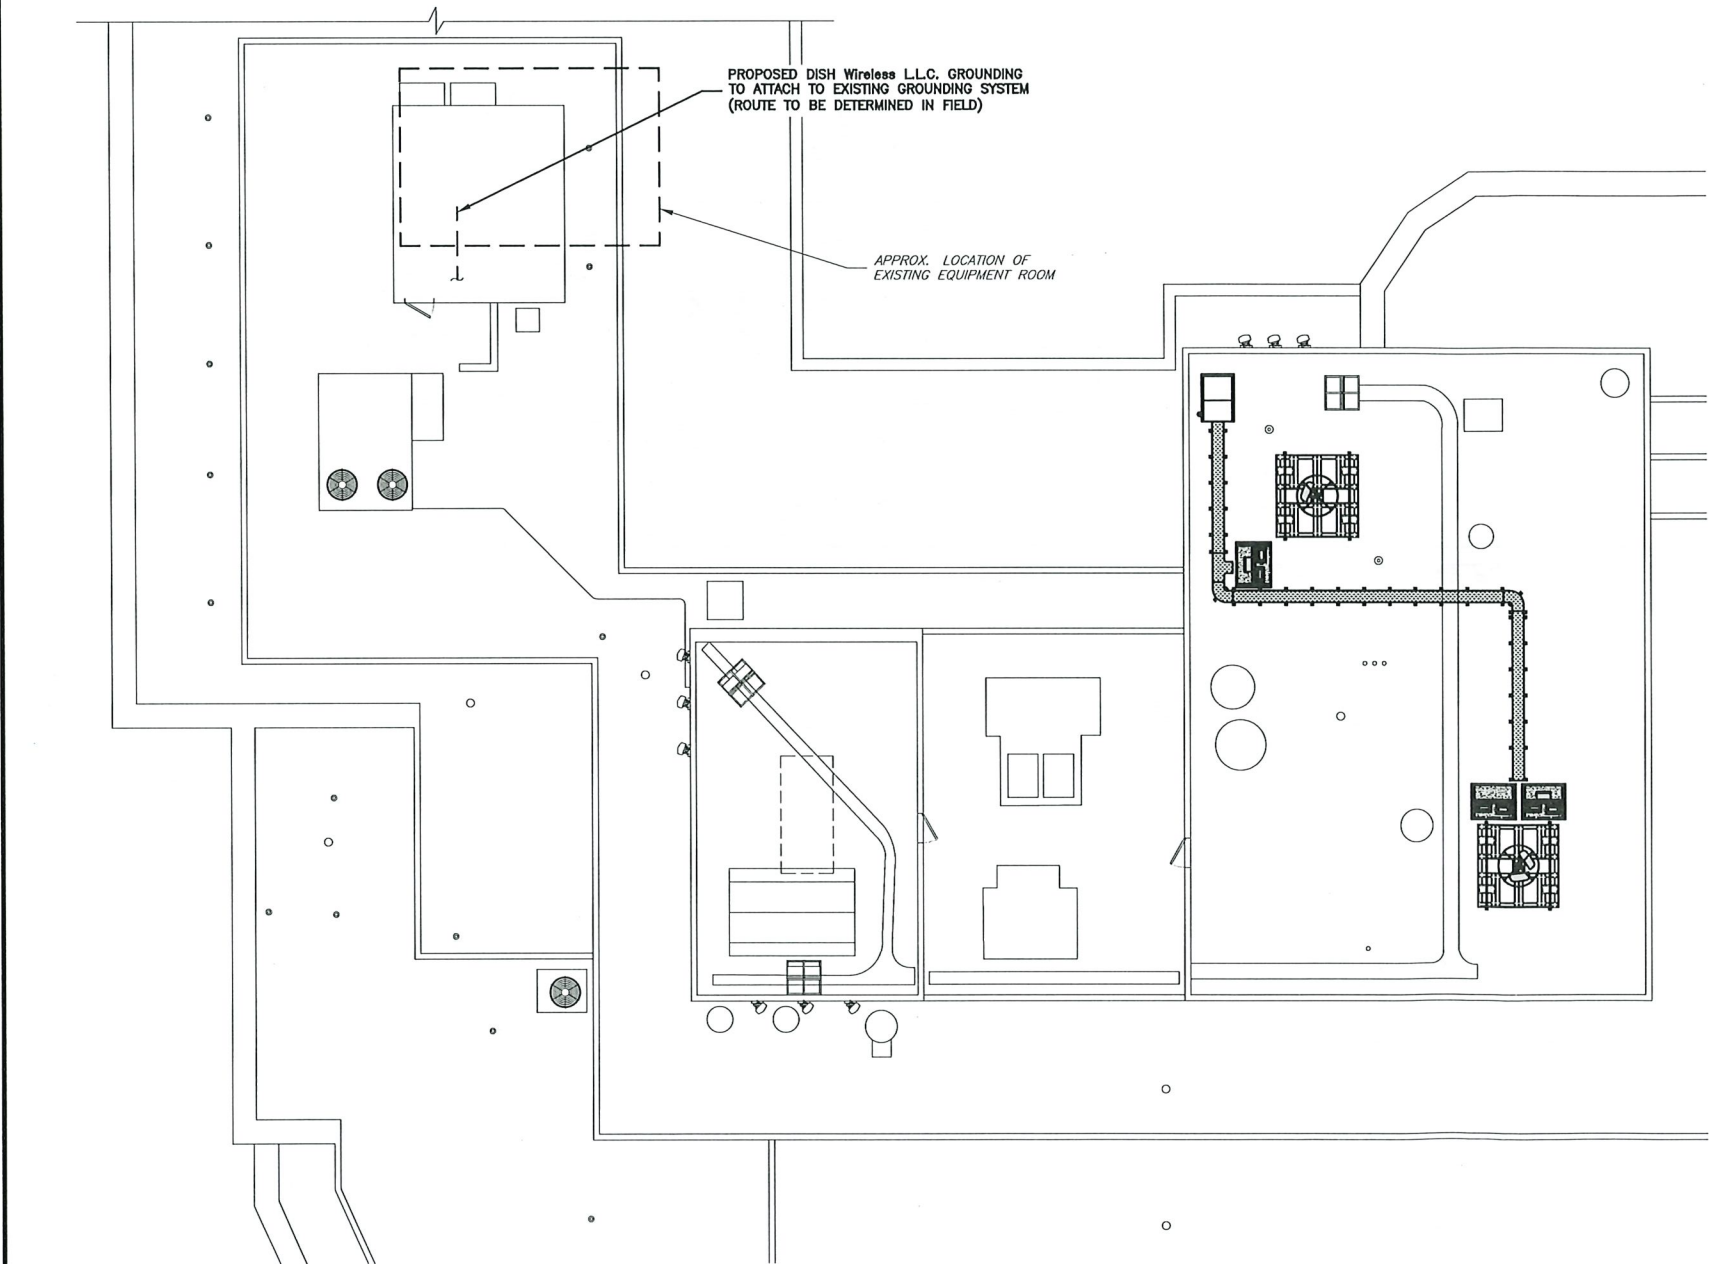

GROUNDING PLAN

 

1

GROUNDING KEY NOTES

NO SCALE

2

- EXOTHERMIC CONNECTION
- MECHANICAL CONNECTION
- GROUND BUS BAR
- GROUND ROD
- TEST GROUND ROD WITH INSPECTION SLEEVE
- #6 AWG STRANDED & INSULATED
- - - - - #2 AWG SOLID COPPER TINNED
- ▲ BUSS BAR INSULATOR

GROUNDING LEGEND

- GROUNDING IS SHOWN DIAGRAMMATICALLY ONLY.
- CONTRACTOR SHALL GROUND ALL EQUIPMENT AS A COMPLETE SYSTEM. GROUNDING SHALL BE IN COMPLIANCE WITH NEC SECTION 250 AND DISH Wireless L.L.C. GROUNDING AND BONDING REQUIREMENTS AND MANUFACTURER'S SPECIFICATIONS.
- ALL GROUND CONDUCTORS SHALL BE COPPER; NO ALUMINUM CONDUCTORS SHALL BE USED.
- NO EXOTHERMIC WELDING ON ROOFTOP

GROUNDING ROOFTOP KEY NOTES

- (A) EXTERIOR GROUND RING: #2 AWG SOLID COPPER, BURIED AT A DEPTH OF AT LEAST 30 INCHES BELOW GRADE, OR 6 INCHES BELOW THE FROST LINE AND APPROXIMATELY 24 INCHES FROM THE EXTERIOR WALL OR FOOTING.
- (B) ROOFTOP GROUND SYSTEM: THE GROUND SYSTEM USING MINIMUM #2 AWG SOLID COPPER CONDUCTORS.
- (C) INTERIOR GROUND RING: #2 AWG STRANDED GREEN INSULATED COPPER CONDUCTOR EXTENDED AROUND THE PERIMETER OF THE EQUIPMENT AREA. ALL NON-TELECOMMUNICATIONS RELATED METALLIC OBJECTS FOUND WITHIN A SITE SHALL BE GROUNDED TO THE INTERIOR GROUND RING WITH #6 AWG STRANDED GREEN INSULATED CONDUCTOR.
- (D) BOND TO INTERIOR GROUND RING: #2 AWG SOLID TINNED COPPER WIRE. PRIMARY BONDS SHALL BE PROVIDED AT LEAST AT FOUR POINTS ON THE INTERIOR GROUND RING, LOCATED AT THE CORNERS OF THE BUILDING OR ROOM.
- (E) GROUND ROD: UL LISTED COPPER CLAD STEEL. MINIMUM 1/2" DIAMETER BY EIGHT FEET LONG. GROUND RODS SHALL BE INSTALLED WITH INSPECTION SLEEVES. GROUND RODS SHALL BE DRIVEN TO THE DEPTH OF GROUND RING CONDUCTOR.
- (F) CELL REFERENCE GROUND BAR (CRGB): POINT OF GROUND REFERENCE FOR ALL COMMUNICATIONS EQUIPMENT FRAMES. ALL BONDS ARE MADE WITH #2 AWG UNLESS NOTED OTHERWISE STRANDED GREEN INSULATED COPPER CONDUCTORS. BOND TO COMMON BUILDING GROUND SYSTEM WITH (2) #2 SOLID TINNED COPPER CONDUCTORS.
- (G) HATCH PLATE GROUND BAR: BOND TO THE COMMON BUILDING GROUND SYSTEM WITH TWO #2 AWG STRANDED GREEN INSULATED COPPER CONDUCTORS. WHEN A HATCH-PLATE AND A CELL REFERENCE GROUND BAR ARE BOTH PRESENT, THE CRGB MUST BE CONNECTED TO THE HATCH-PLATE AND TO THE INTERIOR GROUND RING USING (2) TWO #2 AWG STRANDED GREEN INSULATED COPPER CONDUCTORS EACH.
- (H) EXTERIOR CABLE ENTRY PORT GROUND BARS: LOCATED AT THE ENTRANCE TO THE CELL SITE ROOM. BOND TO GROUND RING WITH A #2 AWG SOLID TINNED COPPER CONDUCTORS WITH MECHANICAL CONNECTIONS.
- (J) TELCO GROUND BAR: BOND TO BOTH CELL REFERENCE GROUND BAR OR EXTERIOR GROUND RING.
- (K) FRAME BONDING: THE BONDING POINT FOR TELECOM EQUIPMENT FRAMES SHALL BE THE GROUND BUS THAT IS NOT ISOLATED FROM THE EQUIPMENTS METAL FRAMEWORK.
- (L) INTERIOR UNIT BONDS: METAL FRAMES, CABINETS AND INDIVIDUAL METALLIC UNITS LOCATED WITH THE AREA OF THE INTERIOR GROUND RING REQUIRE A #6 AWG STRANDED GREEN INSULATED COPPER BOND TO THE INTERIOR GROUND RING.
- (M) FENCE AND GATE GROUNDING: METAL FENCES SHALL BE BONDED TO THE COMMON BUILDING GROUND SYSTEM WITH A #2 AWG SOLID TINNED COPPER CONDUCTOR AT AN INTERVAL NOT EXCEEDING 25 FEET. BONDS SHALL BE MADE AT EACH GATE POST AND ACROSS GATE OPENINGS.
- (N) EXTERIOR UNIT BONDS: METALLIC OBJECTS, EXTERNAL TO OR MOUNTED TO THE BUILDING, SHALL BE BONDED TO THE COMMON BUILDING GROUND SYSTEM. USING #2 TINNED SOLID COPPER WIRE
- (P) ICE BRIDGE SUPPORTS: EACH ICE BRIDGE LEG SHALL BE BONDED TO THE GROUND RING WITH #2 AWG BARE TINNED COPPER CONDUCTOR. PROVIDE EXOTHERMIC WELDS AT BOTH THE ICE BRIDGE LEG AND BURIED GROUND RING.
- (Q) DURING ALL DC POWER SYSTEM CHANGES INCLUDING DC SYSTEM CHANGE OUTS, RECTIFIER REPLACEMENTS OR ADDITIONS, BREAKER DISTRIBUTION CHANGES, BATTERY ADDITIONS, BATTERY REPLACEMENTS AND INSTALLATIONS OR CHANGES TO DC CONVERTER SYSTEMS IT SHALL BE REQUIRED THAT SERVICE CONTRACTORS VERIFY ALL DC POWER SYSTEMS ARE EQUIPPED WITH A MASTER DC SYSTEM RETURN GROUND CONDUCTOR FROM THE DC POWER SYSTEM COMMON RETURN BUS DIRECTLY CONNECTED TO THE CELL SITE REFERENCE GROUND BAR
- (R) ROOFTOP COLLECTOR BUSS BAR IS TO BE MECHANICALLY BONDED TO COMMON BUILDING GROUND SYSTEM. REFER TO DISH Wireless L.L.C. GROUNDING NOTES.



5701 SOUTH SANTA FE DRIVE
LITTLETON, CO 80120



NB+C ENGINEERING SERVICES, LLC.

300 UNICORN PARK DRIVE
SUITE 0501
WOBURN, MA 01801
(978) 856-8308



IT IS A VIOLATION OF LAW FOR ANY PERSON, UNLESS THEY ARE ACTING UNDER THE DIRECTION OF A LICENSED PROFESSIONAL ENGINEER, TO ALTER THIS DOCUMENT.

DRAWN BY: CHECKED BY: APPROVED BY:

CWE NSB DRG

RFDS REV #: 0

CONSTRUCTION DOCUMENTS

SUBMITTALS		
REV	DATE	DESCRIPTION
0	01/11/24	ISSUED FOR CONSTRUCTION
1	08/07/24	REVISED UTILITY ROUTING
2	03/14/25	REVISED PER COMMENTS

A&E PROJECT NUMBER

100753

DISH Wireless L.L.C.
PROJECT INFORMATION



BOBOS00341B

1 BRATTLE SQUARE
CAMBRIDGE, MA 02138

SHEET TITLE
GROUNDING PLANS
AND NOTES

SHEET NUMBER




G-1

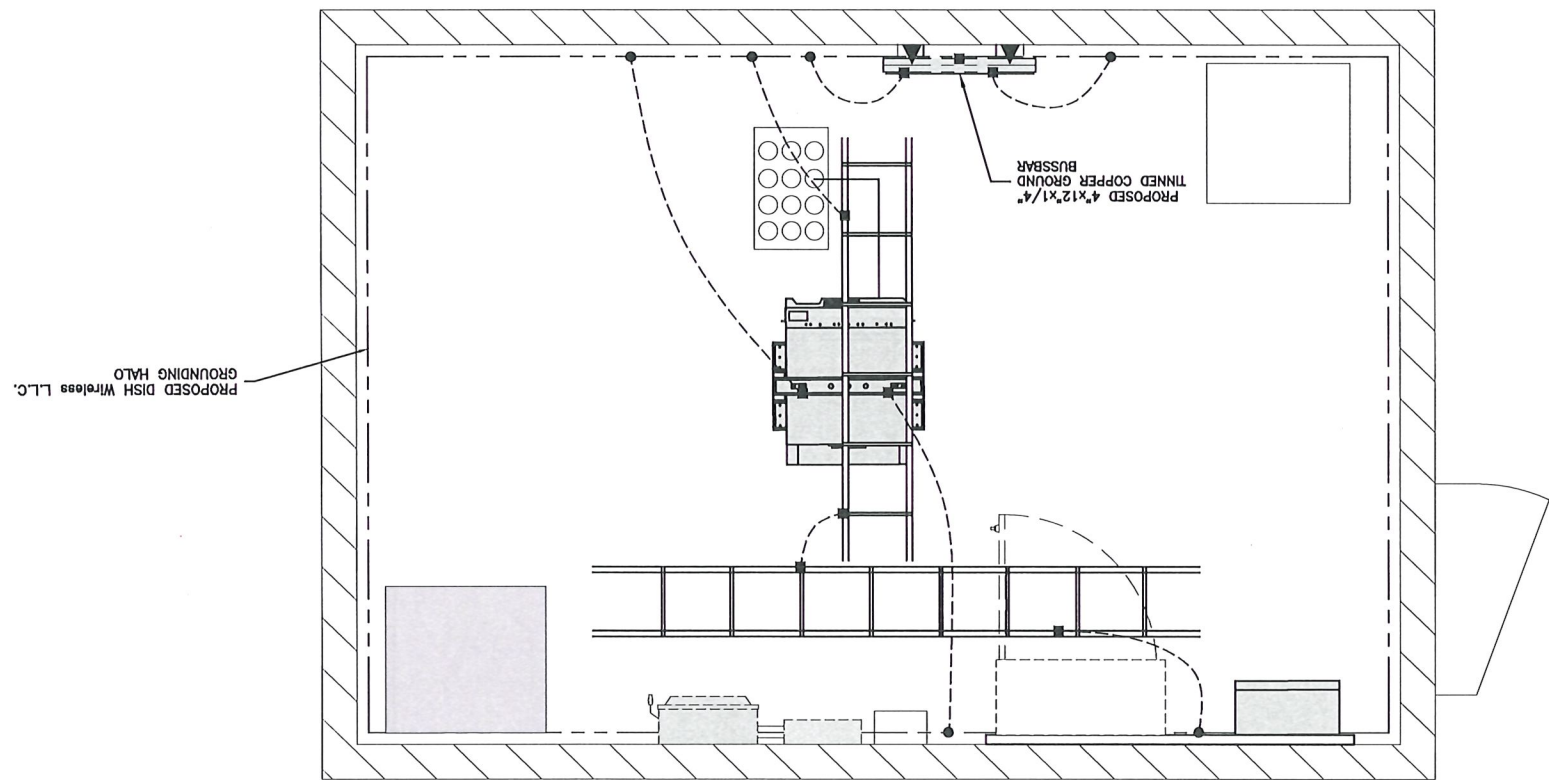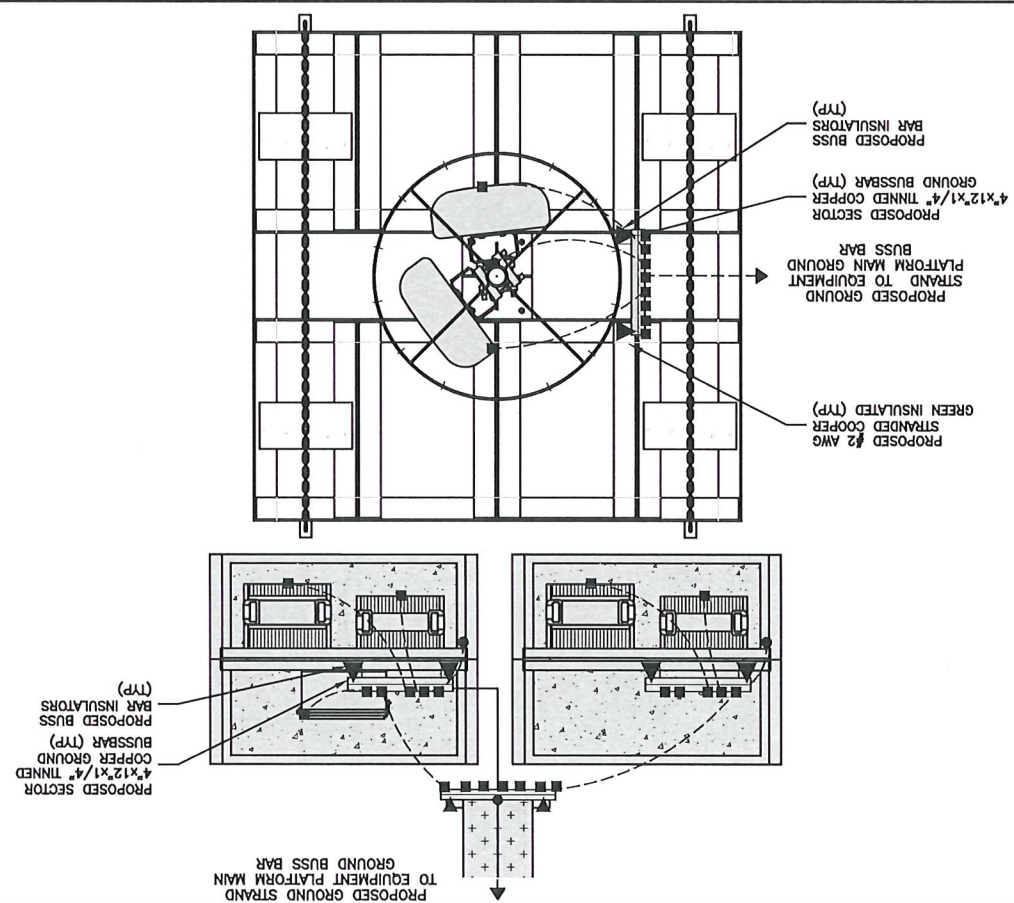

NOTE

EQUIPMENT CABINET OMITTED FOR CLARITY

TYPICAL ROOFTOP EQUIPMENT GROUNDING PLAN		TYPICAL ROOFTOP ANTENNA GROUNDING PLAN	
1	NO SCALE	2	NO SCALE
NOT USED		NOT USED	
3	NO SCALE	2	NO SCALE

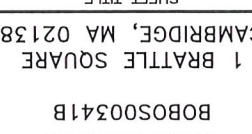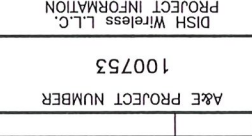
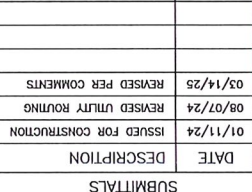
			
5701 SOUTH SANTA FE DRIVE LITTLETON, CO 80120			
			
TOTALY COMMITTED.			
NB+C ENGINEERING SERVICES, LLC.			
700 UNICORN PARK DRIVE SUITE 0501 WOBURN, MA 01801 (978) 856-8308			
			
IT IS A VIOLATION OF LAW FOR ANY PERSON, UNLESS THEY ARE ACTING UNDER THE DIRECTION OF A LICENSED PROFESSIONAL ENGINEER, TO ALTER THIS DOCUMENT. DRAWN BY: _____ CHECKED BY: _____ APPROVED BY: _____ CWE _____ NSB _____ DRG _____ RFD# REV #: _____ 0			
CONSTRUCTION DOCUMENTS SUBMITTALS			
REV	DATE	DESCRIPTION	
0	01/11/24	ISSUED FOR CONSTRUCTION	
1	08/07/24	REVISED UTILITY ROUTING	
2	03/14/25	REVISED PER COMMENTS	
A&E PROJECT NUMBER			
100753			
DISH Wireless LLC. PROJECT INFORMATION			
BOBOS00341B			
1 BRATTLE SQUARE CAMBRIDGE, MA 02138			
SHEET TITLE			
GROUNDING DETAILS			
SHEET NUMBER			
G-2			



nb+c ENGINEERING SERVICES, LLC.
300 UNICORN PARK DRIVE
SUITE 0501
WOBRUN, MA 01801
(978) 856-9308

dish
wireless.

1. EXOTHERMIC WELD (2) TWO, #2 AWG BARE TINNED SOLID COPPER CONDUCTORS TO GROUND BAR. ROUTE CONDUCTORS TO BURIED GROUND RING AND PROVIDE PARALLEL EXOTHERMIC WELD.
2. ALL EXTERIOR GROUNDING HARDWARE SHALL BE STAINLESS STEEL 3/8" DIAMETER OR LARGER. ALL HARDWARE 18-8 STAINLESS STEEL INCLUDING LOCK WASHERS, COAT ALL SURFACES WITH AN ANTI-OXIDANT COMPOUND BEFORE MATING.
3. FOR GROUND BOND TO STEEL ONLY: COAT ALL SURFACES WITH AN ANTI-OXIDANT COMPOUND BEFORE MATING.
4. DO NOT INSTALL CABLE GROUNDING KIT AT A BEND AND ALWAYS DIRECT GROUND CONDUCTOR DOWN TO GROUNDING BUS.
5. NUT & WASHER SHALL BE PLACED ON THE FRONT SIDE OF THE GROUND BAR AND BOLTED ON THE BACK SIDE.
6. ALL GROUNDING PARTS AND EQUIPMENT TO BE SUPPLIED AND INSTALLED BY CONTRACTOR.
7. THE CONTRACTOR SHALL BE RESPONSIBLE FOR INSTALLING ADDITIONAL GROUND BAR AS REQUIRED.
8. ENSURE THE WIRE INSULATION TERMINATION IS WITHIN 1/8" OF THE BARREL (NO SHINERS).

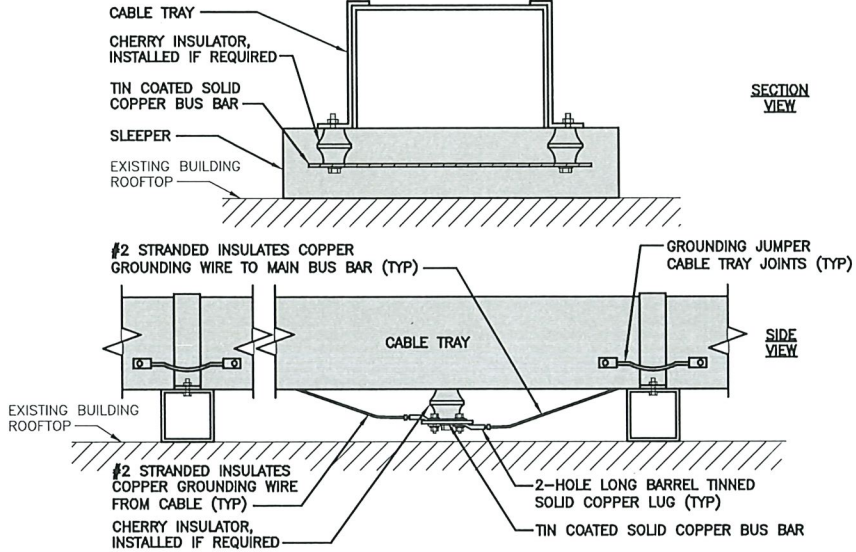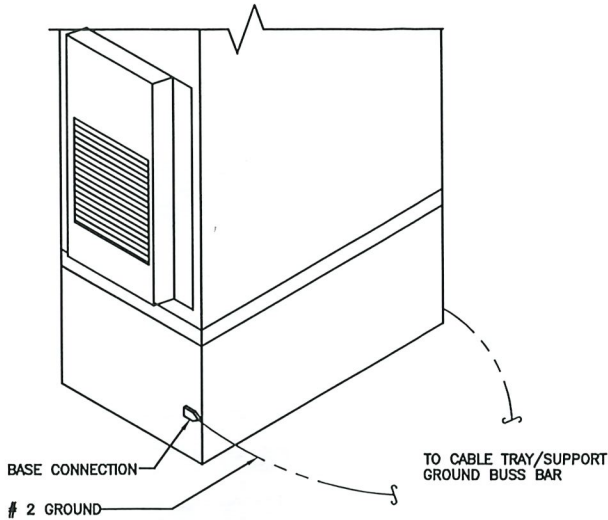

TYPICAL GROUNDING NOTES

NO SCALE

1

OUTDOOR CABINET GROUNDING


NO SCALE

2

TYPICAL CABLE TRAY GROUND BUSS BAR



NO SCALE

3

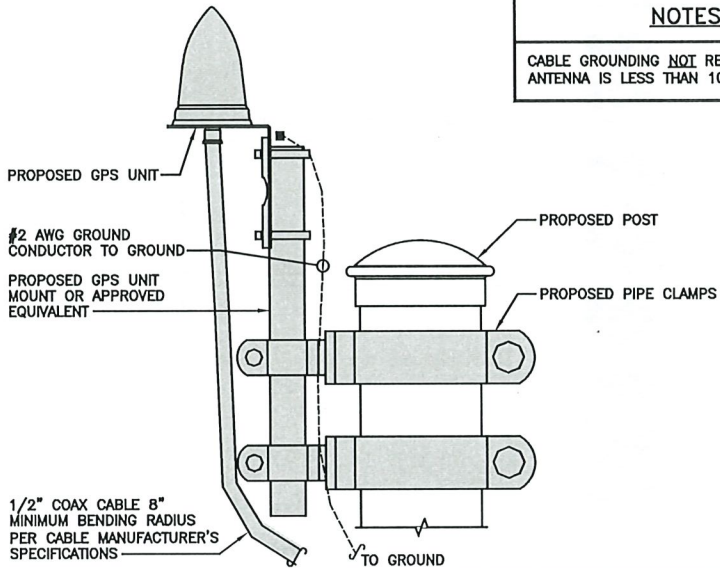

NOTES

CABLE GROUNDING NOT REQUIRED WHEN ANTENNA IS LESS THAN 10' FROM CABINET

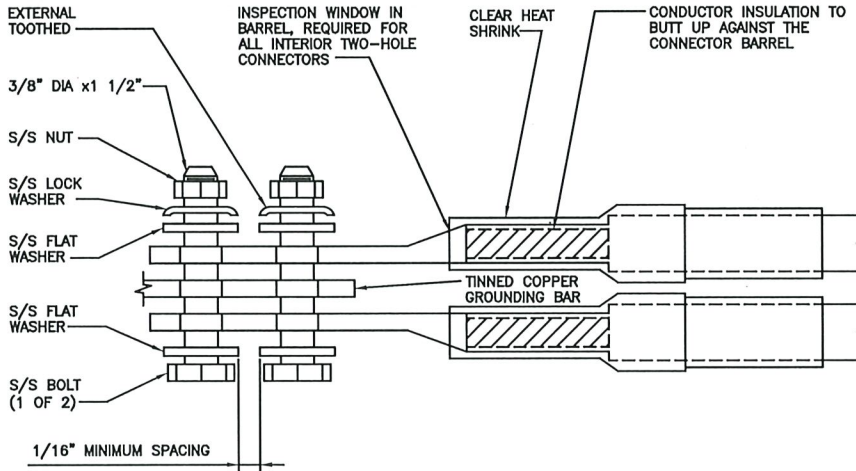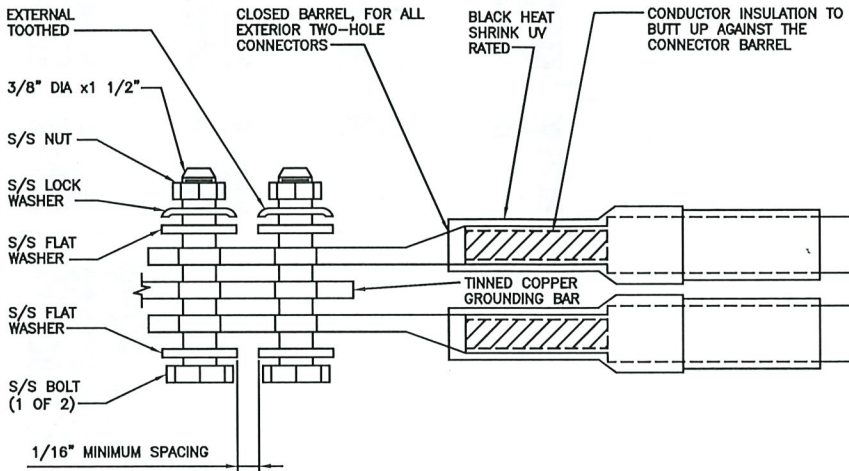

TYPICAL GPS UNIT GROUNDING

NO SCALE

4

TYPICAL EXTERIOR TWO HOLE LUG


NO SCALE

5

TYPICAL INTERIOR TWO HOLE LUG

NO SCALE


6

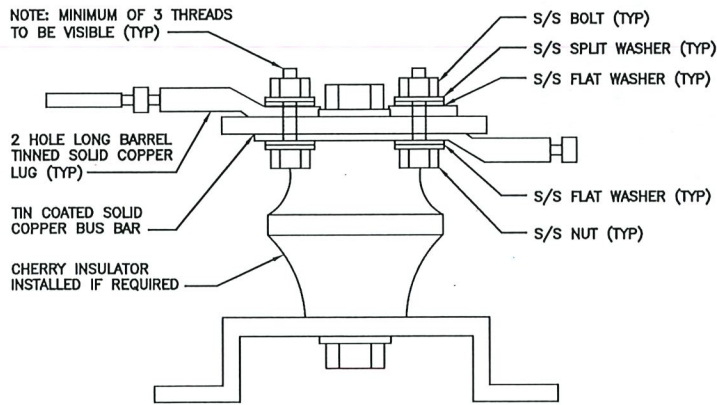

LUG DETAIL

NO SCALE


7

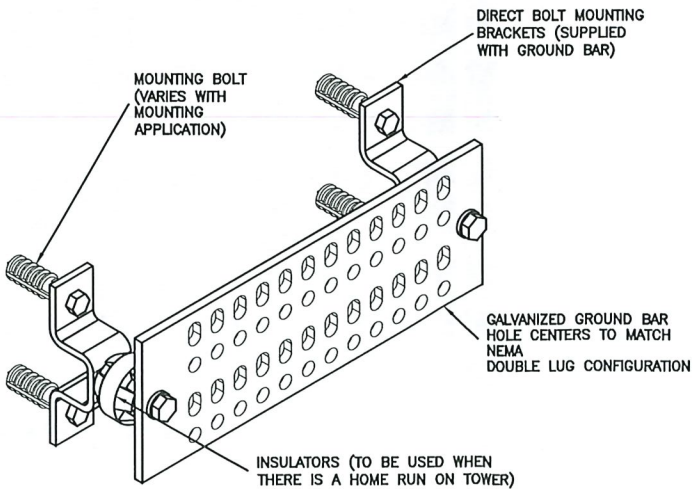

GROUND BAR DETAIL

NO SCALE

8

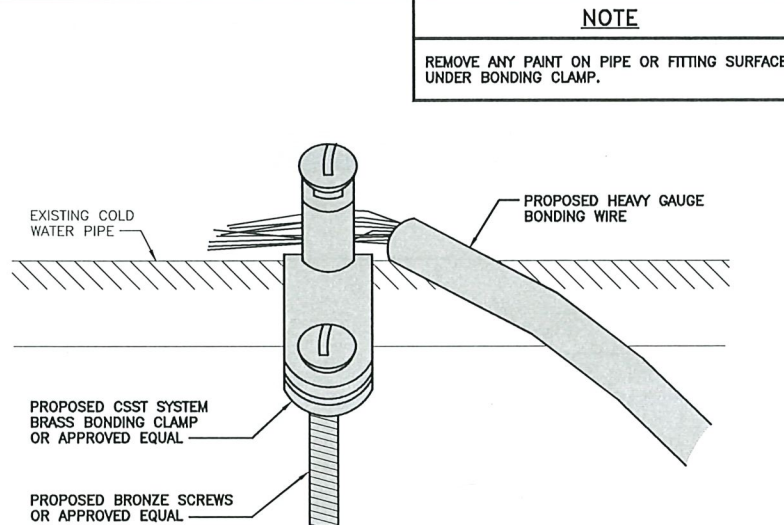

TYPICAL COLD WATER CONDUIT GROUNDING DETAIL

NO SCALE

9

dish
wireless.

5701 SOUTH SANTA FE DRIVE
LITTLETON, CO 80120

NB+C
TOTALLY COMMITTED.

NB+C ENGINEERING SERVICES, LLC.

300 UNICORN PARK DRIVE
SUITE 0501
WOBBURN, MA 01801
(978) 856-8308



IT IS A VIOLATION OF LAW FOR ANY PERSON, UNLESS THEY ARE ACTING UNDER THE DIRECTION OF A LICENSED PROFESSIONAL ENGINEER, TO ALTER THIS DOCUMENT.

DRAWN BY: CHECKED BY: APPROVED BY:

CWE NSB DRG

RFDS REV #: 0

CONSTRUCTION DOCUMENTS

SUBMITTALS

REV	DATE	DESCRIPTION
0	01/11/24	ISSUED FOR CONSTRUCTION
1	08/07/24	REVISED UTILITY ROUTING
2	03/14/25	REVISED PER COMMENTS

A&E PROJECT NUMBER

100753

DISH Wireless L.L.C.
PROJECT INFORMATION


BOBOS00341B

1 BRATTLE SQUARE
CAMBRIDGE, MA 02138

SHEET TITLE
GROUNDING DETAILS






SHEET NUMBER

G-3



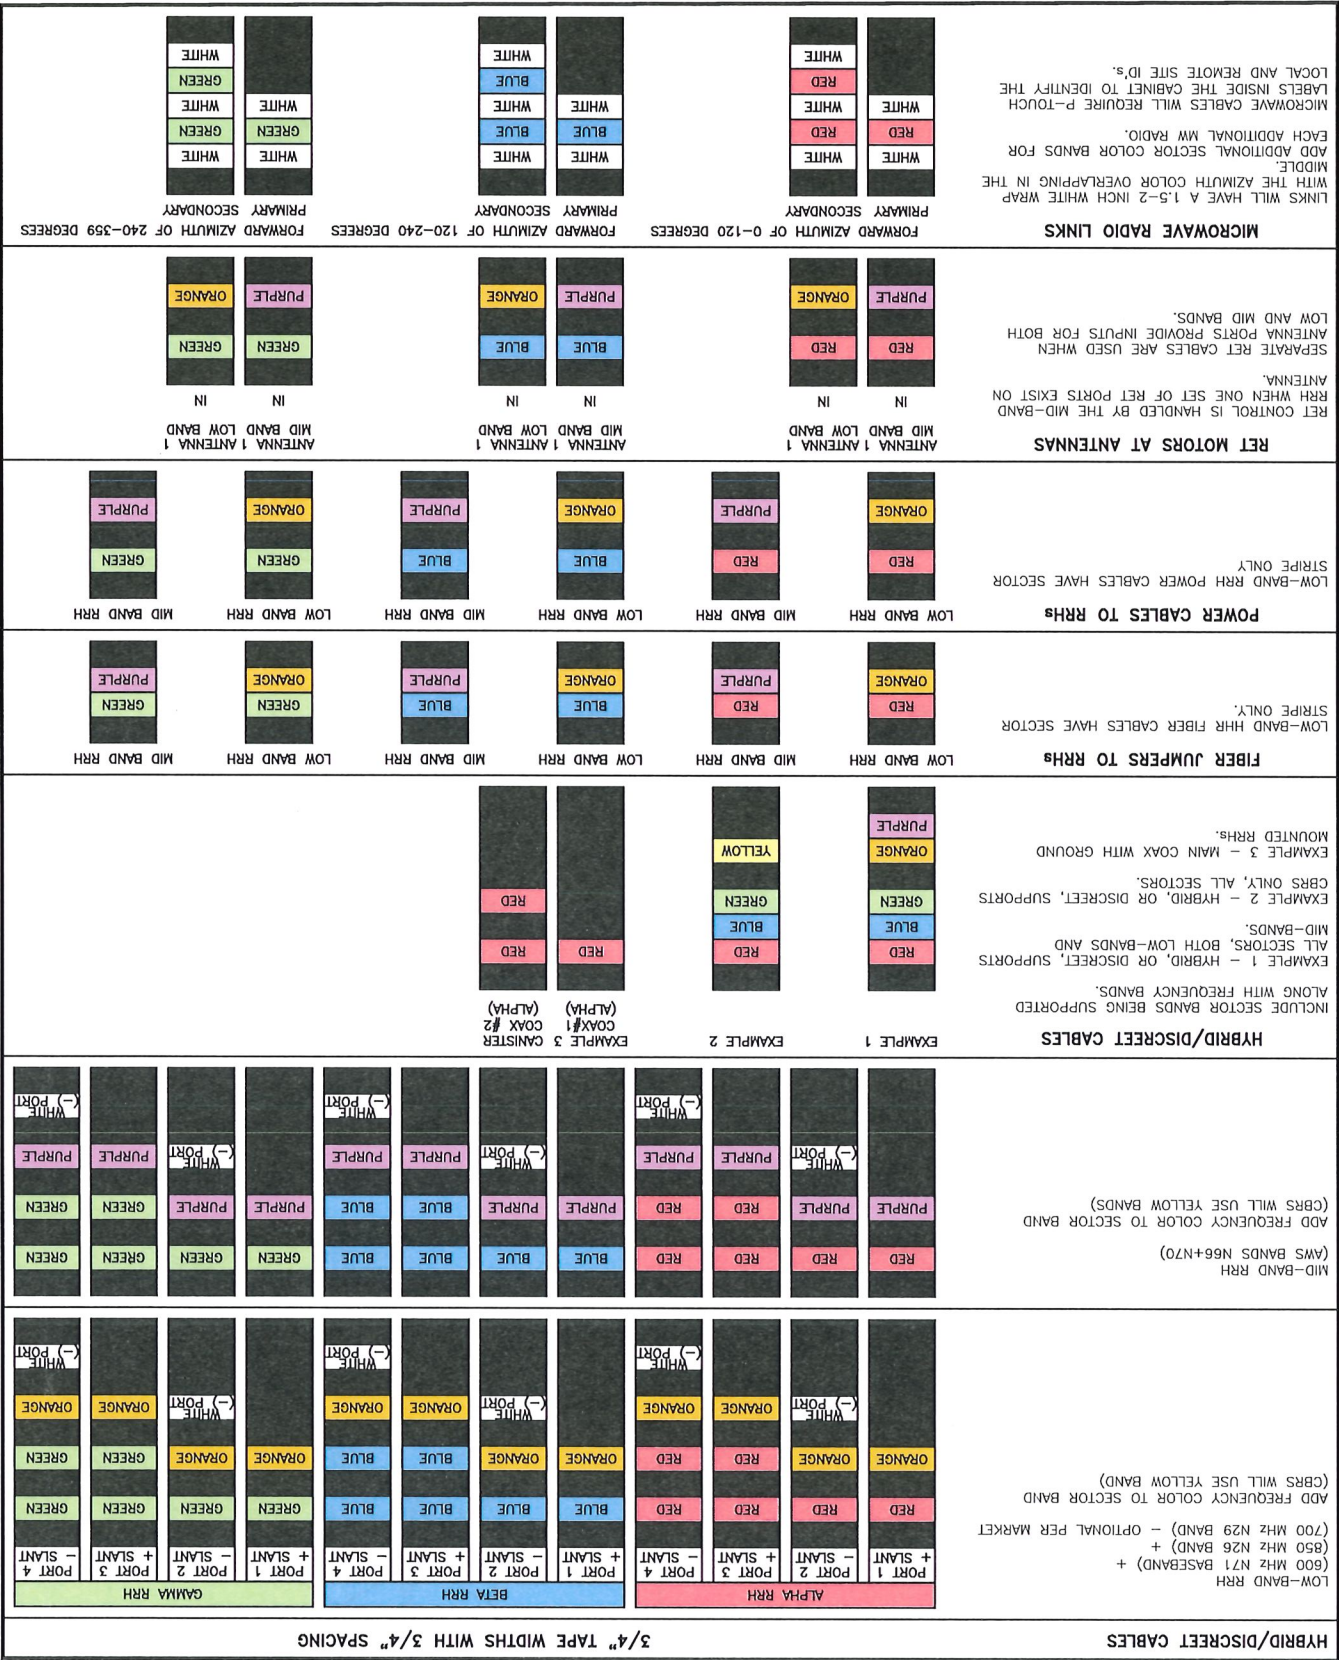


RF CABLE COLOR CODES

NO SCALE

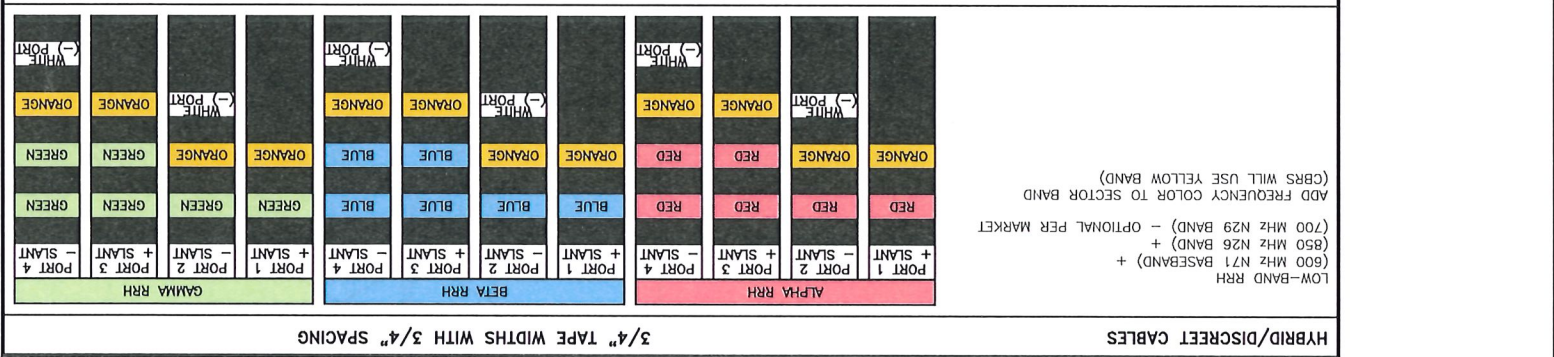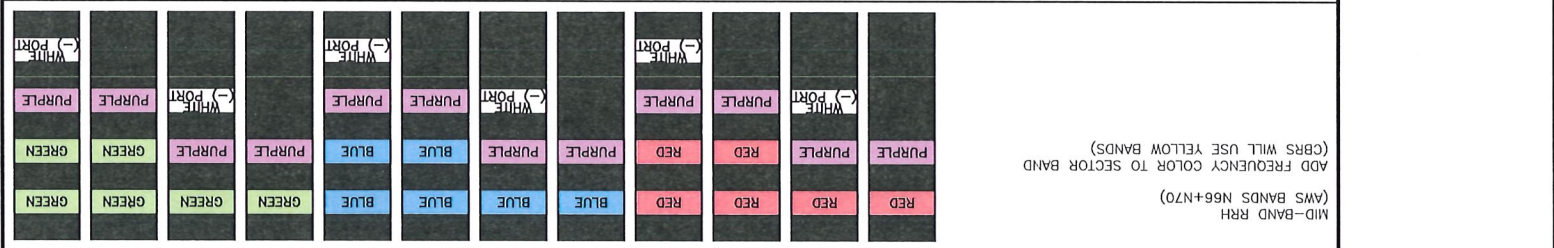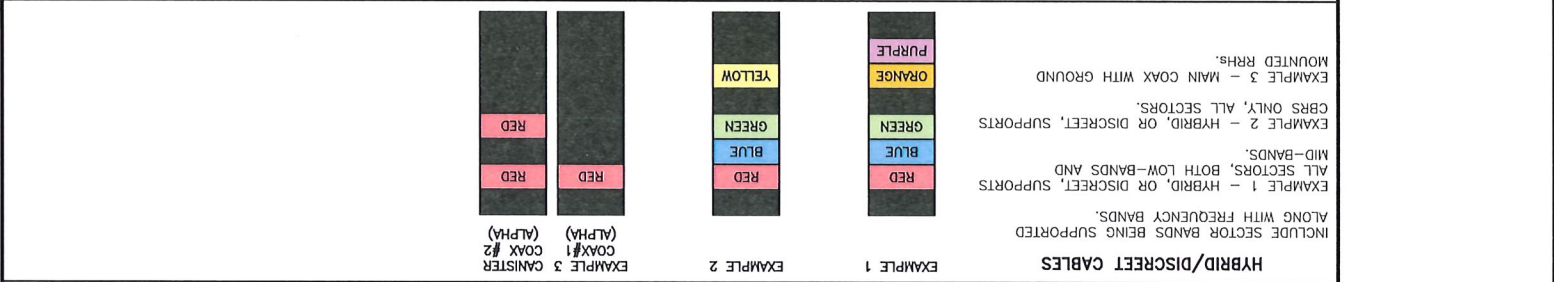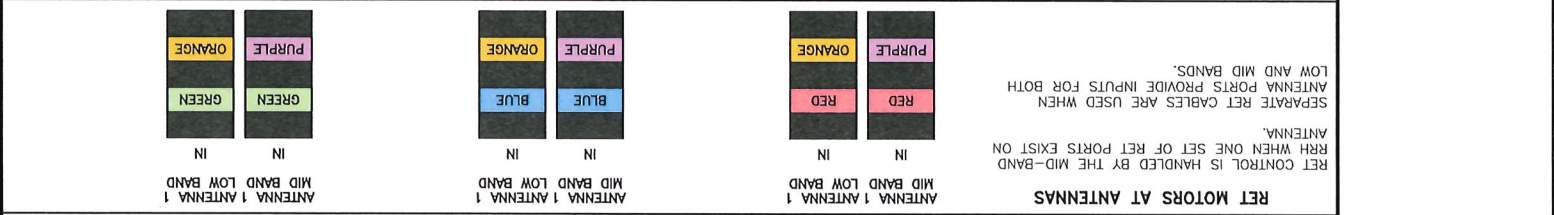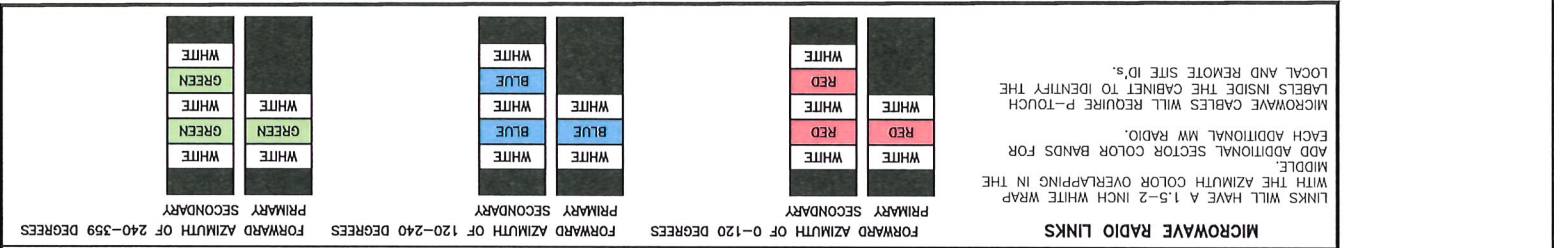

NOT USED

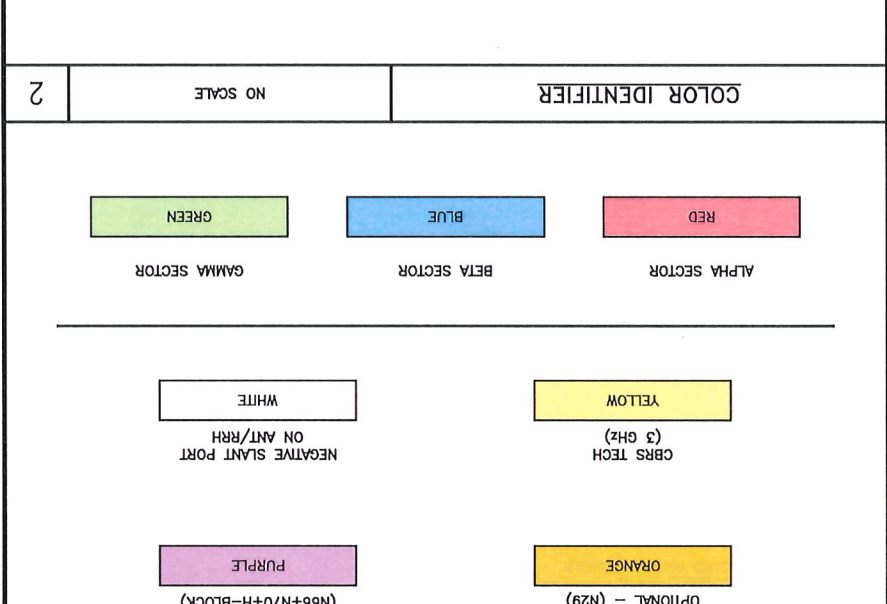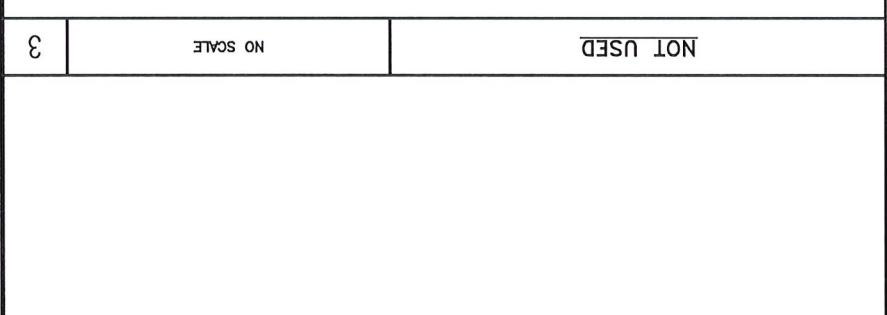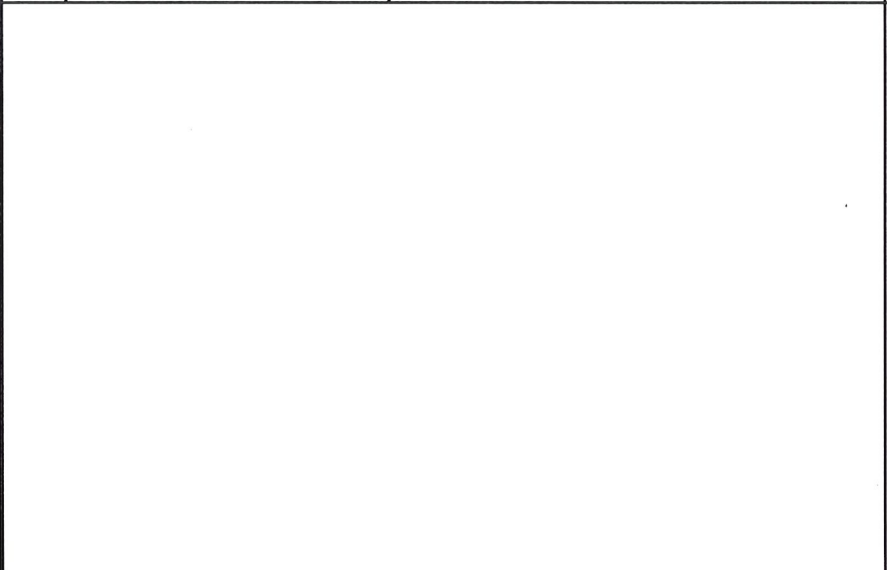

RF-1

SHEET NUMBER

CABLE COLOR CODE

RF

SHEET TITLE

1 BRATTLE SQUARE

CAMBRIDGE, MA 02138

PROJECT INFORMATION

BOBOS00341B

100753

A&E PROJECT NUMBER

REV

DATE

DESCRIPTION

0

01/11/24

ISSUED FOR CONSTRUCTION

1

08/07/24

REVISED UTILITY ROUTING

2

03/14/25

REVISED PER COMMENTS

SUBMITTALS

CONSTRUCTION DOCUMENTS

RDS REV #:

0

DRAWN BY:

CHECKED BY:

APPROVED BY:

CWE

NSB

DRG

IT IS A VIOLATION OF LAW FOR ANY PERSON, UNLESS THEY ARE ACTING UNDER THE DIRECTION OF A LICENSED PROFESSIONAL ENGINEER, TO ALTER THIS DOCUMENT.

PROFESSIONAL ENGINEER

REGISTERED

NO. 50019

KRISHNAVEN KRIJANWALA

300 UNICORN PARK DRIVE

SUITE 0501

WOBURN, MA 01801

(978) 856-8308

NB+C ENGINEERING SERVICES, LLC.

701 SOUTH SANTA FE DRIVE

LITTLETON, CO 80120

wireless.

The diagram illustrates the structure of the DNA template and the chemical environments of the bases. The DNA double helix is shown at the top, with the top strand containing six 'X' markers and the bottom strand having corresponding gaps. Below the DNA are several horizontal bars representing different chemical environments: a hatched bar, a dashed bar, a solid bar, a cross-hatched bar, and a hatched bar. Below these bars are five rows of labels: W, UGP, UGT, OHP, OHT, UGT/P, AGP, AGT, and AGT/P, each with five horizontal lines connecting them to the bars above.

W.P.

XX
X-X

XX
X-X



IN	INCH
INT	INTERIOR
LB(S)	POUND(S)
LF	LINEAR FEET
LTE	LONG TERM EVOLUTION
MAS	MASONRY
MAX	MAXIMUM
MB	MACHINE BOLT
MECH	MECHANICAL
MFR	MANUFACTURER
MGB	MASTER GROUND BAR
MIN	MINIMUM
MISC	MISCELLANEOUS
MTL	METAL
MTS	MANUAL TRANSFER SWITCH
MW	MICROWAVE
NEC	NATIONAL ELECTRIC CODE
NM	NEWTON METERS
NO.	NUMBER
#	NUMBER
NTS	NOT TO SCALE
OC	ON-CENTER
OSHA	OCCUPATIONAL SAFETY AND HEALTH ADMINISTRATION
OPNG	OPENING
P/C	PRECAST CONCRETE
PCS	PERSONAL COMMUNICATION SERVICES
PCU	PRIMARY CONTROL UNIT
PRC	PRIMARY RADIO CABINET
PP	POLARIZING PRESERVING
PSF	POUNDS PER SQUARE FOOT
PSI	POUNDS PER SQUARE INCH
PT	PRESSURE TREATED
PWR	POWER CABINET
QTY	QUANTITY
RAD	RADIUS
RECT	RECTIFIER
REF	REFERENCE
REINF	REINFORCEMENT
REQ'D	REQUIRED
RET	REMOTE ELECTRIC TILT
RF	RADIO FREQUENCY
RMC	RIGID METALLIC CONDUIT
RRH	REMOTE RADIO HEAD
RRU	REMOTE RADIO UNIT
RWY	RACEWAY
SCH	SCHEDULE
SHT	SHEET
SIAD	SMART INTEGRATED ACCESS DEVICE
SIM	SIMILAR
SPEC	SPECIFICATION
SQ	SQUARE
SS	STAINLESS STEEL
STD	STANDARD
STL	STEEL
TEMP	TEMPORARY
THK	THICKNESS
TMA	TOWER MOUNTED AMPLIFIER
TN	TOE NAIL
TOA	TOP OF ANTENNA
TOC	TOP OF CURB
TOF	TOP OF FOUNDATION
TOP	TOP OF PLATE (PARAPET)
TOS	TOP OF STEEL
TOW	TOP OF WALL
TVSS	TRANSIENT VOLTAGE SURGE SUPPRESSION
TYP	TYPICAL
UG	UNDERGROUND
UL	UNDERWRITERS LABORATORY
UNO	UNLESS NOTED OTHERWISE
UMTS	UNIVERSAL MOBILE TELECOMMUNICATIONS SYSTEM
UPS	UNINTERRUPTIBLE POWER SYSTEM (DC POWER PLANT)
VIF	VERIFIED IN FIELD
W	WIDE
W/	WITH
WD	WOOD
WP	WEATHERPROOF
WT	WEIGHT

IN	INCH
INT	INTERIOR
LB(S)	POUND(S)
LF	LINEAR FEET
LTE	LONG TERM EVOLUTION
MAS	MASONRY
MAX	MAXIMUM
MB	MACHINE BOLT
MECH	MECHANICAL
MFR	MANUFACTURER
MGB	MASTER GROUND BAR
MIN	MINIMUM
MISC	MISCELLANEOUS
MTL	METAL
MTS	MANUAL TRANSFER SWITCH
MW	MICROWAVE
NEC	NATIONAL ELECTRIC CODE
NM	NEWTON METERS
NO.	NUMBER
#	NUMBER
NTS	NOT TO SCALE
OC	ON-CENTER
OSHA	OCCUPATIONAL SAFETY AND HEALTH
OPNG	OPENING
P/C	PRECAST CONCRETE
PCS	PERSONAL COMMUNICATIONS
PCU	PRIMARY CONTROL UNIT
PRC	PRIMARY RADIO CABINET
PP	POLARIZING PRESERVING
PSF	POUNDS PER SQUARE
PSI	POUNDS PER SQUARE
PT	PRESSURE TREATED
PWR	POWER CABINET
QTY	QUANTITY
RAD	RADIUS
RECT	RECTIFIER
REF	REFERENCE
REINF	REINFORCEMENT
REQ'D	REQUIRED
RET	REMOTE ELECTRIC TILT
RF	RADIO FREQUENCY
RMG	RIGID METALLIC CONDUIT
RRH	REMOTE RADIO HEAD
RRU	REMOTE RADIO UNIT
RWY	RACEWAY
SCH	SCHEDULE
SHT	SHEET
SIAD	SMART INTEGRATED ACCESS
SIM	SIMILAR
SPEC	SPECIFICATION
SQ	SQUARE
SS	STAINLESS STEEL
STD	STANDARD
STL	STEEL
TEMP	TEMPORARY
THK	THICKNESS
TMA	TOWER MOUNTED AMP
TN	TOE NAIL
TOA	TOP OF ANTENNA
TOC	TOP OF CURB
TOF	TOP OF FOUNDATION
TOP	TOP OF PLATE (PARAPET)
TOS	TOP OF STEEL
TOW	TOP OF WALL
TVSS	TRANSIENT VOLTAGE SUPPRESSOR
TYP	TYPICAL
UG	UNDERGROUND
UL	UNDERWRITERS LABORATORY
UNO	UNLESS NOTED OTHERWISE
UMTS	UNIVERSAL MOBILE TELECOMMUNICATIONS
UPS	UNINTERRUPTIBLE POWER SUPPLY
VIF	VERIFIED IN FIELD
W	WIDE
W/	WITH
WD	WOOD
WP	WEATHERPROOF
WT	WEIGHT

GN-1

ABBREVIATIONS

TYPE	COLOR	COLOR CODE PURPOSE
INFORMATION	GREEN	"INFORMATIONAL SIGN" TO NOTIFY OTHERS OF SITE OWNERSHIP & CONTACT NUMBER AND POTENTIAL RF EXPOSURE.
NOTICE	BLUE	"NOTICE BEYOND THIS POINT" RF FIELDS BEYOND THIS POINT MAY EXCEED THE FCC GENERAL PUBLIC EXPOSURE LIMIT. OBEY ALL POSTED SIGNS AND SITE GUIDELINES FOR WORKING IN RF ENVIRONMENTS. IN ACCORDANCE WITH FEDERAL COMMUNICATIONS COMMISSION RULES ON RADIO FREQUENCY EMISSIONS 47 CFR-1.1307(b).
CAUTION	YELLOW	"CAUTION BEYOND THIS POINT" RF FIELDS BEYOND THIS POINT MAY EXCEED THE FCC GENERAL PUBLIC EXPOSURE LIMIT. OBEY ALL POSTED SIGNS AND SITE GUIDELINES FOR WORKING IN RF ENVIRONMENTS. IN ACCORDANCE WITH FEDERAL COMMUNICATIONS COMMISSION RULES ON RADIO FREQUENCY EMISSIONS 47 CFR-1.1307(b).
WARNING	ORANGE/RED	"WARNING BEYOND THIS POINT" RF FIELDS AT THIS SITE EXCEED FCC RULES FOR HUMAN EXPOSURE. FAILURE TO OBEY ALL POSTED SIGNS AND SITE GUIDELINES FOR WORKING IN RF ENVIRONMENTS COULD RESULT IN SERIOUS INJURY. IN ACCORDANCE WITH FEDERAL COMMUNICATIONS COMMISSION RULES ON RADIO FREQUENCY EMISSIONS 47 CFR-1.1307(b).

SIGN PLACEMENT:

- RF SIGNAGE PLACEMENT SHALL FOLLOW THE RECOMMENDATIONS OF AN EXISTING EME REPORT, CREATED BY A THIRD PARTY PREVIOUSLY AUTHORIZED BY DISH Wireless L.L.C.
- INFORMATION SIGN (GREEN) SHALL BE LOCATED ON EXISTING DISH Wireless L.L.C. EQUIPMENT.
 - A) IF THE INFORMATION SIGN IS A STICKER, IT SHALL BE PLACED ON EXISTING DISH Wireless L.L.C. EQUIPMENT CABINET.
 - B) IF THE INFORMATION SIGN IS A METAL SIGN IT SHALL BE PLACED ON EXISTING DISH Wireless L.L.C. H-FRAME WITH A SECURE ATTACH METHOD.
- IF EME REPORT IS NOT AVAILABLE AT THE TIME OF CREATION OF CONSTRUCTION DOCUMENTS; PLEASE CONTACT DISH Wireless L.L.C. CONSTRUCTION MANAGER FOR FURTHER INSTRUCTION ON HOW TO PROCEED.
- 1. FOR DISH Wireless L.L.C. LOGO, SEE DISH Wireless L.L.C. DESIGN SPECIFICATIONS (PROVIDED BY DISH Wireless L.L.C.).
- 2. SITE ID SHALL BE APPLIED TO SIGNS USING "LASER ENGRAVING" OR ANY OTHER WEATHER RESISTANT METHOD (DISH Wireless L.L.C. APPROVAL REQUIRED).
- 3. TEXT FOR SIGNAGE SHALL INDICATE CORRECT SITE NAME AND NUMBER AS PER DISH Wireless L.L.C. CONSTRUCTION MANAGER RECOMMENDATIONS.
- 4. CABINET/SHELTER MOUNTING APPLICATION REQUIRES ANOTHER PLATE APPLIED TO THE FACE OF THE CABINET WITH WATER PROOF POLYURETHANE ADHESIVE.
- 5. ALL SIGNS WILL BE SECURED WITH EITHER STAINLESS STEEL ZIP TIES OR STAINLESS STEEL TECH SCREWS.
- 6. ALL SIGNS TO BE 8.5"x11" AND MADE WITH 0.04" OF ALUMINUM MATERIAL.

NOTICE



Transmitting Antenna(s)

Radio frequency fields beyond this point MAY EXCEED the FCC Occupational exposure limit.

ObeY all posted signs and site guidelines for working in radio frequency environments.

Call the DISH Wireless L.L.C. NOC at 1-866-624-6874 prior to working beyond this point.

Site ID: _____



THIS SIGN IS FOR REFERENCE PURPOSES ONLY

CAUTION



Transmitting Antenna(s)

Radio frequency fields beyond this point MAY EXCEED the FCC Occupational exposure limit.

ObeY all posted signs and site guidelines for working in radio frequency environments.

Call the DISH Wireless L.L.C. NOC at 1-866-624-6874 prior to working beyond this point.

Site ID: _____



THIS SIGN IS FOR REFERENCE PURPOSES ONLY

WARNING



Transmitting Antenna(s)

Radio frequency fields beyond this point EXCEED the FCC Occupational exposure limit.

ObeY all posted signs and site guidelines for working in radio frequency environments.

Call the DISH Wireless L.L.C. NOC at 1-866-624-6874 prior to working beyond this point.

Site ID: _____



THIS SIGN IS FOR REFERENCE PURPOSES ONLY

INFORMATION

This is an access point to an area with transmitting antennas.

ObeY all signs and barriers beyond this point.

Call the DISH Wireless L.L.C. NOC at 1-866-624-6874

Site ID: _____



THIS SIGN IS FOR REFERENCE PURPOSES ONLY



5701 SOUTH SANTA FE DRIVE
LITTLETON, CO 80120

NA+C
TOTALLY COMMITTED.

300 UNICORN PARK DRIVE
SUITE 0501
WOBBURN, MA 01801
(978) 856-8308



IT IS A VIOLATION OF LAW FOR ANY PERSON, UNLESS THEY ARE ACTING UNDER THE DIRECTION OF A LICENSED PROFESSIONAL ENGINEER, TO ALTER THIS DOCUMENT.

DRAWN BY: _____
CHECKED BY: _____
CWE NSB DRG

RFDS REV #: 0

CONSTRUCTION DOCUMENTS

SUBMITTALS

REV	DATE	DESCRIPTION
0	01/11/24	ISSUED FOR CONSTRUCTION
1	08/07/24	REVISED UTILITY ROUTING
2	03/14/25	REVISED PER COMMENTS

A&E PROJECT NUMBER 100753

DISH Wireless L.L.C.
PROJECT INFORMATION
BOBOS00341B

1 BRATTLE SQUARE
CAMBRIDGE, MA 02138

SHEET TITLE
RF SIGNAGE

SHEET NUMBER
GN-2

SITE ACTIVITY REQUIREMENTS:

1. NOTICE TO PROCEED – NO WORK SHALL COMMENCE PRIOR TO CONTRACTOR RECEIVING A WRITTEN NOTICE TO PROCEED (NTP) AND THE ISSUANCE OF A PURCHASE ORDER. PRIOR TO ACCESSING/ENTERING THE SITE YOU MUST CONTACT THE DISH Wireless L.L.C. AND TOWER OWNER NOC & THE DISH Wireless L.L.C. AND TOWER OWNER CONSTRUCTION MANAGER.
2. "LOOK UP" – DISH Wireless L.L.C. AND TOWER OWNER SAFETY CLIMB REQUIREMENT:
- THE INTEGRITY OF THE SAFETY CLIMB AND ALL COMPONENTS OF THE CLIMBING FACILITY SHALL BE CONSIDERED DURING ALL STAGES OF DESIGN, INSTALLATION, AND INSPECTION. TOWER MODIFICATION, MOUNT REINFORCEMENTS, AND/OR EQUIPMENT INSTALLATIONS SHALL NOT COMPROMISE THE INTEGRITY OR FUNCTIONAL USE OF THE SAFETY CLIMB OR ANY COMPONENTS OF THE CLIMBING FACILITY ON THE STRUCTURE. THIS SHALL INCLUDE, BUT NOT BE LIMITED TO: PINCHING OF THE WIRE ROPE, BENDING OF THE WIRE ROPE FROM ITS SUPPORTS, DIRECT CONTACT OR CLOSE PROXIMITY TO THE WIRE ROPE WHICH MAY CAUSE FRICTIONAL WEAR, IMPACT TO THE ANCHORAGE POINTS IN ANY WAY, OR TO IMPEDE/BLOCK ITS INTENDED USE. ANY COMPROMISED SAFETY CLIMB, INCLUDING EXISTING CONDITIONS MUST BE TAGGED OUT AND REPORTED TO YOUR DISH Wireless L.L.C. AND DISH Wireless L.L.C. AND TOWER OWNER POC OR CALL THE NOC TO GENERATE A SAFETY CLIMB MAINTENANCE AND CONTRACTOR NOTICE TICKET.
3. PRIOR TO THE START OF CONSTRUCTION, ALL REQUIRED JURISDICTIONAL PERMITS SHALL BE OBTAINED. THIS INCLUDES, BUT IS NOT LIMITED TO, BUILDING, ELECTRICAL, MECHANICAL, FIRE, FLOOD ZONE, ENVIRONMENTAL, AND ZONING. AFTER ONSITE ACTIVITIES AND CONSTRUCTION ARE COMPLETED, ALL REQUIRED PERMITS SHALL BE SATISFIED AND CLOSED OUT ACCORDING TO LOCAL JURISDICTIONAL REQUIREMENTS.
4. ALL CONSTRUCTION MEANS AND METHODS; INCLUDING BUT NOT LIMITED TO, ERECTION PLANS, RIGGING PLANS, CLIMBING PLANS, AND RESCUE PLANS SHALL BE THE RESPONSIBILITY OF THE GENERAL CONTRACTOR RESPONSIBLE FOR THE EXECUTION OF THE WORK CONTAINED HEREIN, AND SHALL MEET ANSI/ASSE A10.48 (LATEST EDITION); FEDERAL, STATE, AND LOCAL REGULATIONS; AND ANY APPLICABLE INDUSTRY CONSENSUS STANDARDS RELATED TO THE CONSTRUCTION ACTIVITIES BEING PERFORMED. ALL RIGGING PLANS SHALL ADHERE TO ANSI/ASSE A10.48 (LATEST EDITION) AND DISH Wireless L.L.C. AND TOWER OWNER STANDARDS, INCLUDING THE REQUIRED INVOLVEMENT OF A QUALIFIED ENGINEER FOR CLASS IV CONSTRUCTION, TO CERTIFY THE SUPPORTING STRUCTURE(S) IN ACCORDANCE WITH ANSI/TIA-322 (LATEST EDITION).
5. ALL SITE WORK TO COMPLY WITH DISH Wireless L.L.C. AND TOWER OWNER INSTALLATION STANDARDS FOR CONSTRUCTION ACTIVITIES ON DISH Wireless L.L.C. AND TOWER OWNER TOWER SITE AND LATEST VERSION OF ANSI/TIA-1019-A-2012 "STANDARD FOR INSTALLATION, ALTERATION, AND MAINTENANCE OF ANTENNA SUPPORTING STRUCTURES AND ANTENNAS."
6. IF THE SPECIFIED EQUIPMENT CAN NOT BE INSTALLED AS SHOWN ON THESE DRAWINGS, THE CONTRACTOR SHALL PROPOSE AN ALTERNATIVE INSTALLATION FOR APPROVAL BY DISH Wireless L.L.C. AND TOWER OWNER PRIOR TO PROCEEDING WITH ANY SUCH CHANGE OF INSTALLATION.
7. ALL MATERIALS FURNISHED AND INSTALLED SHALL BE IN STRICT ACCORDANCE WITH ALL APPLICABLE CODES, REGULATIONS AND ORDINANCES. CONTRACTOR SHALL ISSUE ALL APPROPRIATE NOTICES AND COMPLY WITH ALL LAWS, ORDINANCES, RULES, REGULATIONS AND LAWFUL ORDERS OF ANY PUBLIC AUTHORITY REGARDING THE PERFORMANCE OF THE WORK. ALL WORK CARRIED OUT SHALL COMPLY WITH ALL APPLICABLE MUNICIPAL AND UTILITY COMPANY SPECIFICATIONS AND LOCAL JURISDICTIONAL CODES, ORDINANCES AND APPLICABLE REGULATIONS.
8. THE CONTRACTOR SHALL INSTALL ALL EQUIPMENT AND MATERIALS IN ACCORDANCE WITH MANUFACTURER'S RECOMMENDATIONS UNLESS SPECIFICALLY STATED OTHERWISE.
9. THE CONTRACTOR SHALL CONTACT UTILITY LOCATING SERVICES INCLUDING PRIVATE LOCATES SERVICES PRIOR TO THE START OF CONSTRUCTION.
10. ALL EXISTING ACTIVE SEWER, WATER, GAS, ELECTRIC AND OTHER UTILITIES WHERE ENCOUNTERED IN THE WORK, SHALL BE PROTECTED AT ALL TIMES AND WHERE REQUIRED FOR THE PROPER EXECUTION OF THE WORK, SHALL BE RELOCATED AS DIRECTED BY CONTRACTOR. EXTREME CAUTION SHOULD BE USED BY THE CONTRACTOR WHEN EXCAVATING OR DRILLING PIERS AROUND OR NEAR UTILITIES. CONTRACTOR SHALL PROVIDE SAFETY TRAINING FOR THE WORKING CREW. THIS WILL INCLUDE BUT NOT BE LIMITED TO A) FALL PROTECTION B) CONFINED SPACE C) ELECTRICAL SAFETY D) TRENCHING AND EXCAVATION E) CONSTRUCTION SAFETY PROCEDURES.
11. ALL SITE WORK SHALL BE AS INDICATED ON THE STAMPED CONSTRUCTION DRAWINGS AND DISH PROJECT SPECIFICATIONS, LATEST APPROVED REVISION.
12. CONTRACTOR SHALL KEEP THE SITE FREE FROM ACCUMULATING WASTE MATERIAL, DEBRIS, AND TRASH AT THE COMPLETION OF THE WORK. IF NECESSARY, RUBBISH, STUMPS, DEBRIS, STICKS, STONES AND OTHER REFUSE SHALL BE REMOVED FROM THE SITE AND DISPOSED OF LEGALLY.
13. ALL EXISTING INACTIVE SEWER, WATER, GAS, ELECTRIC AND OTHER UTILITIES, WHICH INTERFERE WITH THE EXECUTION OF THE WORK, SHALL BE REMOVED AND/OR CAPPED, PLUGGED OR OTHERWISE DISCONTINUED AT POINTS WHICH WILL NOT INTERFERE WITH THE EXECUTION OF THE WORK, SUBJECT TO THE APPROVAL OF DISH Wireless L.L.C. AND TOWER OWNER, AND/OR LOCAL UTILITIES.
14. THE CONTRACTOR SHALL PROVIDE SITE SIGNAGE IN ACCORDANCE WITH THE TECHNICAL SPECIFICATION FOR SITE SIGNAGE REQUIRED BY LOCAL JURISDICTION AND SIGNAGE REQUIRED ON INDIVIDUAL PIECES OF EQUIPMENT, ROOMS, AND SHELTERS.
15. THE SITE SHALL BE GRADED TO CAUSE SURFACE WATER TO FLOW AWAY FROM THE CARRIER'S EQUIPMENT AND TOWER AREAS.
16. THE SUB GRADE SHALL BE COMPACTED AND BROUGHT TO A SMOOTH UNIFORM GRADE PRIOR TO FINISHED SURFACE APPLICATION.
17. THE AREAS OF THE OWNERS PROPERTY DISTURBED BY THE WORK AND NOT COVERED BY THE TOWER, EQUIPMENT OR DRIVEWAY, SHALL BE GRADED TO A UNIFORM SLOPE, AND STABILIZED TO PREVENT EROSION AS SPECIFIED ON THE CONSTRUCTION DRAWINGS AND/OR PROJECT SPECIFICATIONS.
18. CONTRACTOR SHALL MINIMIZE DISTURBANCE TO EXISTING SITE DURING CONSTRUCTION. EROSION CONTROL MEASURES, IF REQUIRED DURING CONSTRUCTION, SHALL BE IN CONFORMANCE WITH THE LOCAL GUIDELINES FOR EROSION AND SEDIMENT CONTROL.
19. THE CONTRACTOR SHALL PROTECT EXISTING IMPROVEMENTS, PAVEMENTS, CURBS, LANDSCAPING AND STRUCTURES. ANY DAMAGED PART SHALL BE REPAIRED AT CONTRACTOR'S EXPENSE TO THE SATISFACTION OF OWNER.
20. CONTRACTOR SHALL LEGALLY AND PROPERLY DISPOSE OF ALL SCRAP MATERIALS SUCH AS COAXIAL CABLES AND OTHER ITEMS REMOVED FROM THE EXISTING FACILITY. ANTENNAS AND RADIOS REMOVED SHALL BE RETURNED TO THE OWNER'S DESIGNATED LOCATION.
21. CONTRACTOR SHALL LEAVE PREMISES IN CLEAN CONDITION. TRASH AND DEBRIS SHOULD BE REMOVED FROM SITE ON A DAILY BASIS.
22. NO FILL OR EMBANKMENT MATERIAL SHALL BE PLACED ON FROZEN GROUND. FROZEN MATERIALS, SNOW OR ICE SHALL NOT BE PLACED IN ANY FILL OR EMBANKMENT.

GENERAL NOTES:

- 1.FOR THE PURPOSE OF CONSTRUCTION DRAWING, THE FOLLOWING DEFINITIONS SHALL APPLY:
- CONTRACTOR:GENERAL CONTRACTOR RESPONSIBLE FOR CONSTRUCTION
- CARRIER:DISH Wireless L.L.C.
- TOWER OWNER:TOWER OWNER
2. THESE DRAWINGS HAVE BEEN PREPARED USING STANDARDS OF PROFESSIONAL CARE AND COMPLETENESS NORMALLY EXERCISED UNDER SIMILAR CIRCUMSTANCES BY REPUTABLE ENGINEERS IN THIS OR SIMILAR LOCALITIES. IT IS ASSUMED THAT THE WORK DEPICTED WILL BE PERFORMED BY AN EXPERIENCED CONTRACTOR AND/OR WORKPEOPLE WHO HAVE A WORKING KNOWLEDGE OF THE APPLICABLE CODE STANDARDS AND REQUIREMENTS AND OF INDUSTRY ACCEPTED STANDARD GOOD PRACTICE. AS NOT EVERY CONDITION OR ELEMENT IS (OR CAN BE) EXPLICITLY SHOWN ON THESE DRAWINGS, THE CONTRACTOR SHALL USE INDUSTRY ACCEPTED STANDARD GOOD PRACTICE FOR MISCELLANEOUS WORK NOT EXPLICITLY SHOWN.
3. THESE DRAWINGS REPRESENT THE FINISHED STRUCTURE. THEY DO NOT INDICATE THE MEANS OR METHODS OF CONSTRUCTION. THE CONTRACTOR SHALL BE SOLELY RESPONSIBLE FOR THE CONSTRUCTION MEANS, METHODS, TECHNIQUES, SEQUENCES, AND PROCEDURES. THE CONTRACTOR SHALL PROVIDE ALL MEASURES NECESSARY FOR PROTECTION OF LIFE AND PROPERTY DURING CONSTRUCTION. SUCH MEASURES SHALL INCLUDE, BUT NOT BE LIMITED TO, BRACING, FORMWORK, SHORING, ETC. SITE VISITS BY THE ENGINEER OR HIS REPRESENTATIVE WILL NOT INCLUDE INSPECTION OF THESE ITEMS AND IS FOR STRUCTURAL OBSERVATION OF THE FINISHED STRUCTURE ONLY.
4. NOTES AND DETAILS IN THE CONSTRUCTION DRAWINGS SHALL TAKE PRECEDENCE OVER GENERAL NOTES AND TYPICAL DETAILS. WHERE NO DETAILS ARE SHOWN, CONSTRUCTION SHALL CONFORM TO SIMILAR WORK ON THE PROJECT, AND/OR AS PROVIDED FOR IN THE CONTRACT DOCUMENTS. WHERE DISCREPANCIES OCCUR BETWEEN PLANS, DETAILS, GENERAL NOTES, AND SPECIFICATIONS, THE GREATER, MORE STRICT REQUIREMENTS, SHALL GOVERN. IF FURTHER CLARIFICATION IS REQUIRED CONTACT THE ENGINEER OF RECORD.
5. SUBSTANTIAL EFFORT HAS BEEN MADE TO PROVIDE ACCURATE DIMENSIONS AND MEASUREMENTS ON THE DRAWINGS TO ASSIST IN THE FABRICATION AND/OR PLACEMENT OF CONSTRUCTION ELEMENTS BUT IT IS THE SOLE RESPONSIBILITY OF THE CONTRACTOR TO FIELD VERIFY THE DIMENSIONS, MEASUREMENTS, AND/OR CLEARANCES SHOWN IN THE CONSTRUCTION DRAWINGS PRIOR TO FABRICATION OR CUTTING OF ANY NEW OR EXISTING CONSTRUCTION ELEMENTS. IF IT IS DETERMINED THAT THERE ARE DISCREPANCIES AND/OR CONFLICTS WITH THE CONSTRUCTION DRAWINGS THE ENGINEER OF RECORD IS TO BE NOTIFIED AS SOON AS POSSIBLE.
6. PRIOR TO THE SUBMISSION OF BIDS, THE BIDDING CONTRACTOR SHALL VISIT THE CELL SITE TO FAMILIARIZE WITH THE EXISTING CONDITIONS AND TO CONFIRM THAT THE WORK CAN BE ACCOMPLISHED AS SHOWN ON THE CONSTRUCTION DRAWINGS. ANY DISCREPANCY FOUND SHALL BE BROUGHT TO THE ATTENTION OF CARRIER POC AND TOWER OWNER.
7. ALL MATERIALS FURNISHED AND INSTALLED SHALL BE IN STRICT ACCORDANCE WITH ALL APPLICABLE CODES, REGULATIONS AND ORDINANCES. CONTRACTOR SHALL ISSUE ALL APPROPRIATE NOTICES AND COMPLY WITH ALL LAWS, ORDINANCES, RULES, REGULATIONS AND LAWFUL ORDERS OF ANY PUBLIC AUTHORITY REGARDING THE PERFORMANCE OF THE WORK. ALL WORK CARRIED OUT SHALL COMPLY WITH ALL APPLICABLE MUNICIPAL AND UTILITY COMPANY SPECIFICATIONS AND LOCAL JURISDICTIONAL CODES, ORDINANCES AND APPLICABLE REGULATIONS.
8. UNLESS NOTED OTHERWISE, THE WORK SHALL INCLUDE FURNISHING MATERIALS, EQUIPMENT, APPURTENANCES AND LABOR NECESSARY TO COMPLETE ALL INSTALLATIONS AS INDICATED ON THE DRAWINGS.
9. THE CONTRACTOR SHALL INSTALL ALL EQUIPMENT AND MATERIALS IN ACCORDANCE WITH MANUFACTURER'S RECOMMENDATIONS UNLESS SPECIFICALLY STATED OTHERWISE.
10. IF THE SPECIFIED EQUIPMENT CAN NOT BE INSTALLED AS SHOWN ON THESE DRAWINGS, THE CONTRACTOR SHALL PROPOSE AN ALTERNATIVE INSTALLATION FOR APPROVAL BY THE CARRIER AND TOWER OWNER PRIOR TO PROCEEDING WITH ANY SUCH CHANGE OF INSTALLATION.
11. CONTRACTOR IS TO PERFORM A SITE INVESTIGATION, BEFORE SUBMITTING BIDS, TO DETERMINE THE BEST ROUTING OF ALL CONDUITS FOR POWER, AND TELCO AND FOR GROUNDING CABLES AS SHOWN IN THE POWER, TELCO, AND GROUNDING PLAN DRAWINGS.
12. THE CONTRACTOR SHALL PROTECT EXISTING IMPROVEMENTS, PAVEMENTS, CURBS, LANDSCAPING AND STRUCTURES. ANY DAMAGED PART SHALL BE REPAIRED AT CONTRACTOR'S EXPENSE TO THE SATISFACTION OF DISH Wireless L.L.C. AND TOWER OWNER
13. CONTRACTOR SHALL LEGALLY AND PROPERLY DISPOSE OF ALL SCRAP MATERIALS SUCH AS COAXIAL CABLES AND OTHER ITEMS REMOVED FROM THE EXISTING FACILITY. ANTENNAS REMOVED SHALL BE RETURNED TO THE OWNER'S DESIGNATED LOCATION.
14. CONTRACTOR SHALL LEAVE PREMISES IN CLEAN CONDITION. TRASH AND DEBRIS SHOULD BE REMOVED FROM SITE ON A DAILY BASIS.

dish
wireless.

5701 SOUTH SANTA FE DRIVE
LITTLETON, CO 80120

NB+C
TOTALLY COMMITTED.

NB+C ENGINEERING SERVICES, LLC.

300 UNICORN PARK DRIVE
SUITE 0501
WOBURN, MA 01801
(978) 856-8308



IT IS A VIOLATION OF LAW FOR ANY PERSON,
UNLESS THEY ARE ACTING UNDER THE DIRECTION
OF A LICENSED PROFESSIONAL ENGINEER,
TO ALTER THIS DOCUMENT.

DRAWN BY: CHECKED BY: APPROVED BY:

CWE NSB DRG

RFDS REV #: 0

**CONSTRUCTION
DOCUMENTS**

SUBMITTALS		
REV	DATE	DESCRIPTION
0	01/11/24	ISSUED FOR CONSTRUCTION
1	08/07/24	REVISED UTILITY ROUTING
2	03/14/25	REVISED PER COMMENTS

A&E PROJECT NUMBER
100753

DISH Wireless L.L.C.
PROJECT INFORMATION
BOBOS00341B

**1 BRATTLE SQUARE
CAMBRIDGE, MA 02138**

SHEET TITLE
GENERAL NOTES

SHEET NUMBER
GN-3

1. ALL CONCRETE WORK SHALL BE IN ACCORDANCE WITH THE ACI 301, ACI 318, ACI 336, ASTM A184, ASTM A185 AND THE DESIGN

AND CONSTRUCTION SPECIFICATION FOR CAST-IN-PLACE CONCRETE.

2. UNLESS NOTED OTHERWISE, SOIL BEARING PRESSURE USED FOR DESIGN OF SLABS AND FOUNDATIONS IS ASSUMED TO BE 1000

psf.

3. ALL CONCRETE SHALL HAVE A MINIMUM COMPRESSIVE STRENGTH (f'c) OF 3000 psi AT 28 DAYS, UNLESS NOTED OTHERWISE. NO MORE THAN 90 MINUTES SHALL ELAPSE FROM BATCH TIME TO TIME OF PLACEMENT UNLESS APPROVED BY THE ENGINEER OF RECORD. TEMPERATURE OF CONCRETE SHALL NOT EXCEED 90°F AT TIME OF PLACEMENT.

4. CONCRETE EXPOSED TO FREEZE-THAW CYCLES SHALL CONTAIN AIR ENTRAINING ADMIXTURES. AMOUNT OF AIR ENTRAINMENT TO BE BASED ON SIZE OF AGGREGATE AND F3 CLASS EXPOSURE (VERY SEVERE). CEMENT USED TO BE TYPE II PORTLAND CEMENT WITH A MAXIMUM WATER-TO-CEMENT RATIO (W/C) OF 0.45.

5. ALL STEEL REINFORCING SHALL CONFORM TO ASTM A615. ALL WELDED WIRE FABRIC (WWF) SHALL CONFORM TO ASTM A185. ALL SPICES SHALL BE CLASS "B" TENSION SPLICES, UNLESS NOTED OTHERWISE. ALL HOOKS SHALL BE STANDARD 90 DEGREE HOOKS, UNLESS NOTED OTHERWISE. YIELD STRENGTH (fy) OF STANDARD DEFORMED BARS ARE AS FOLLOWS:

#4 BARS AND SMALLER 40 ksi

#5 BARS AND LARGER 60 ksi

6. THE FOLLOWING MINIMUM CONCRETE COVER SHALL BE PROVIDED FOR REINFORCING STEEL UNLESS SHOWN OTHERWISE ON DRAWINGS:

• CONCRETE CAST AGAINST AND PERMANENTLY EXPOSED TO EARTH 3"

• CONCRETE EXPOSED TO EARTH OR WEATHER:

• #6 BARS AND LARGER 2"

• #5 BARS AND SMALLER 1-1/2"

• CONCRETE NOT EXPOSED TO EARTH OR WEATHER:

• SLAB AND WALLS 3/4"

• BEAMS AND COLUMNS 1-1/2"

7. A TOOLED EDGE OR A 3/4" CHAMFER SHALL BE PROVIDED AT ALL EXPOSED EDGES OF CONCRETE, UNLESS NOTED OTHERWISE, IN ACCORDANCE WITH ACI 301 SECTION 4.2.4.

ELECTRICAL INSTALLATION NOTES:

1. ALL ELECTRICAL WORK SHALL BE PERFORMED IN ACCORDANCE WITH THE PROJECT SPECIFICATIONS, NEC AND ALL APPLICABLE FEDERAL, STATE, AND LOCAL CODES/ORDINANCES.

2. CONDUIT ROUTINGS ARE SCHEMATIC. CONTRACTOR SHALL INSTALL CONDUITS SO THAT ACCESS TO EQUIPMENT IS NOT BLOCKED AND TRIP HAZARDS ARE ELIMINATED.

3. WIRING, RACEWAY AND SUPPORT METHODS AND MATERIALS SHALL COMPLY WITH THE REQUIREMENTS OF THE NEC.

4. ALL CIRCUITS SHALL BE SEGREGATED AND MAINTAIN MINIMUM CABLE SEPARATION AS REQUIRED BY THE NEC.

4.1. ALL EQUIPMENT SHALL BEAR THE UNDERWRITERS LABORATORIES LABEL OF APPROVAL, AND SHALL CONFORM TO REQUIREMENT OF THE NATIONAL ELECTRICAL CODE.

4.2. ALL OVERCURRENT DEVICES SHALL HAVE AN INTERRUPTING CURRENT RATING THAT SHALL BE GREATER THAN THE SHORT CIRCUIT CURRENT TO WHICH THEY ARE SUBJECTED, 22,000 AIC MINIMUM. VERIFY AVAILABLE SHORT CIRCUIT CURRENT DOES NOT EXCEED THE RATING OF ELECTRICAL EQUIPMENT IN ACCORDANCE WITH ARTICLE 110.24 NEC OR THE MOST CURRENT ADOPTED CODE PRE THE GOVERNING JURISDICTION.

5. EACH END OF EVERY POWER PHASE CONDUCTOR, GROUNDING CONDUCTOR, AND TELCO CONDUCTOR OR CABLE SHALL BE LABELED WITH COLOR-CODED INSULATION OR ELECTRICAL TAPE (3M BRAND, 1/2" PLASTIC ELECTRICAL TAPE WITH UV PROTECTION, OR EQUAL). THE IDENTIFICATION METHOD SHALL CONFORM WITH NEC AND OSHA.

6. ALL ELECTRICAL COMPONENTS SHALL BE CLEARLY LABELED WITH LAMICOID TAGS SHOWING THEIR RATED VOLTAGE, PHASE CONFIGURATION, WIRE CONFIGURATION, POWER OR AMPACITY RATING AND BRANCH CIRCUIT ID NUMBERS (i.e. PANEL BOARD AND CIRCUIT ID(S)).

7. PANEL BOARDS (ID NUMBERS) SHALL BE CLEARLY LABELED WITH PLASTIC LABELS.

8. TIE WRAPS ARE NOT ALLOWED.

9. ALL POWER AND EQUIPMENT GROUND WIRING IN TUBING OR CONDUIT SHALL BE SINGLE COPPER CONDUCTOR (#14 OR LARGER) WITH TYPE THHW, THWN, THWN-2, XHHW, XHHW-2, THW, THW-2, RHW, OR RHW-2 INSULATION UNLESS OTHERWISE SPECIFIED.

10. SUPPLEMENTAL EQUIPMENT GROUND WIRING LOCATED INDOORS SHALL BE SINGLE COPPER CONDUCTOR (#6 OR LARGER) WITH TYPE THHW, THWN, THWN-2, XHHW, XHHW-2, THW, THW-2, RHW, OR RHW-2 INSULATION UNLESS OTHERWISE SPECIFIED.

11. POWER AND CONTROL WIRING IN FLEXIBLE CORD SHALL BE MULTI-CONDUCTOR, TYPE SOOW CORD (#14 OR LARGER) UNLESS OTHERWISE SPECIFIED.

12. POWER AND CONTROL WIRING FOR USE IN CABLE TRAY SHALL BE MULTI-CONDUCTOR, TYPE TC CABLE (#14 OR LARGER), WITH TYPE THHW, THWN, THWN-2, XHHW, XHHW-2, THW, THW-2, RHW, OR RHW-2 INSULATION UNLESS OTHERWISE SPECIFIED.

13. ALL POWER AND GROUNDING CONNECTIONS SHALL BE CRIMP-STYLE, COMPRESSION WIRE LUGS AND WIRE NUTS BY THOMAS AND BETTS (OR EQUAL). LUGS AND WIRE NUTS SHALL BE RATED FOR OPERATION NOT LESS THAN 75° C (90° C IF AVAILABLE).

14. RACEWAY AND CABLE TRAY SHALL BE LISTED OR LABELED FOR ELECTRICAL USE IN ACCORDANCE WITH NEMA, UL, ANSI/IEEE AND NEC.

15. ELECTRICAL METALLIC TUBING (EMT), INTERMEDIATE METAL CONDUIT (IMC), OR RIGID METAL CONDUIT (RMC) SHALL BE USED FOR EXPOSED INDOOR LOCATIONS.

16. ELECTRICAL METALLIC TUBING (EMT) OR METAL-CLAD CABLE (MC) SHALL BE USED FOR CONCEALED INDOOR LOCATIONS.

17. SCHEDULE 40 PVC UNDERGROUND ON STRAIGHTS AND SCHEDULE 80 PVC FOR ALL ELBOWS/90s AND ALL APPROVED ABOVE GRADE PVC CONDUIT.

18. LIQUID-TIGHT FLEXIBLE METALLIC CONDUIT (LIQUID-TITE FLEX) SHALL BE USED INDOORS AND OUTDOORS, WHERE VIBRATION OCCURS OR FLEXIBILITY IS NEEDED.

19. CONDUIT AND TUBING FITTINGS SHALL BE THREADED OR COMPRESSION-TYPE AND APPROVED FOR THE LOCATION USED. SET SCREW FITTINGS ARE NOT ACCEPTABLE.

20. CABINETS, BOXES AND WIRE WAYS SHALL BE LABELED FOR ELECTRICAL USE IN ACCORDANCE WITH NEMA, UL, ANSI/IEEE AND THE NEC.

21. WIREWAYS SHALL BE METAL WITH AN ENAMEL FINISH AND INCLUDE A HINGED COVER, DESIGNED TO SWING OPEN DOWNWARDS (WIREFOLDED SPECIMATE WIREWAY).

22. SLOTTED WIRING DUCT SHALL BE PVC AND INCLUDE COVER (PANDUIT TYPE E OR EQUAL).

23. CONDUITS SHALL BE FASTENED SECURELY IN PLACE WITH APPROVED NON-PERFORATED STRAPS AND HANGERS. EXPLOSIVE DEVICES (i.e. POWDER-ACTUATED) FOR ATTACHING HANGERS TO STRUCTURE WILL NOT BE PERMITTED. CLOSELY FOLLOW THE LINES OF THE STRUCTURE, MAINTAIN CLOSE PROXIMITY TO THE STRUCTURE AND KEEP CONDUITS IN TIGHT ENVELOPES. CHANGES IN DIRECTION TO ROUTE AROUND OBSTACLES SHALL BE MADE WITH CONDUIT OUTLET BODIES. CONDUIT SHALL BE INSTALLED IN A NEAT AND WORKMANLIKE MANNER. PARALLEL AND PERPENDICULAR TO STRUCTURE WALL AND CEILING LINES. ALL CONDUIT SHALL BE FISHED TO CLEAR OBSTRUCTIONS. ENDS OF CONDUITS SHALL BE TEMPORARILY CAPPED FLUSH TO FINISH GRADE TO PREVENT CONCRETE, PLASTER OR DIRT FROM ENTERING. CONDUITS SHALL BE RIGIDLY CLAMPED TO BOXES BY GALVANIZED MALLEABLE IRON BUSHING ON INSIDE AND GALVANIZED MALLEABLE IRON LOCKNUT ON OUTSIDE AND INSIDE.

24. EQUIPMENT CABINETS, TERMINAL BOXES AND PULL BOXES SHALL BE GALVANIZED OR EPOXY-COATED SHEET STEEL. SHALL MEET OR EXCEED UL 50 AND BE RATED NEMA 1 (OR BETTER) FOR INTERIOR LOCATIONS AND NEMA 3 (OR BETTER) FOR EXTERIOR LOCATIONS.

25. METAL RECEPTACLE, SWITCH AND DEVICE BOXES SHALL BE GALVANIZED, EPOXY-COATED OR NON-CORRODING; SHALL MEET OR EXCEED UL 514A AND NEMA OS 1 AND BE RATED NEMA 1 (OR BETTER) FOR INTERIOR LOCATIONS AND WEATHER PROTECTED (WP OR BETTER) FOR EXTERIOR LOCATIONS.

26. NONMETALLIC RECEPTACLE, SWITCH AND DEVICE BOXES SHALL MEET OR EXCEED NEMA OS 2 (NEWEST REVISION) AND BE RATED NEMA 1 (OR BETTER) FOR INTERIOR LOCATIONS AND WEATHER PROTECTED (WP OR BETTER) FOR EXTERIOR LOCATIONS.

27. THE CONTRACTOR SHALL NOTIFY AND OBTAIN NECESSARY AUTHORIZATION FROM THE CARRIER AND/OR DISH Wireless L.L.C. AND TOWER OWNER BEFORE COMMENCING WORK ON THE AC POWER DISTRIBUTION PANELS.

28. THE CONTRACTOR SHALL PROVIDE NECESSARY TAGGING ON THE BREAKERS, CABLES AND DISTRIBUTION PANELS IN ACCORDANCE WITH THE APPLICABLE CODES AND STANDARDS TO SAFEGUARD LIFE AND PROPERTY.

29. INSTALL LAMICOID LABEL ON THE METER CENTER TO SHOW "DISH Wireless L.L.C."

30. ALL EMPTY/SPARE CONDUITS THAT ARE INSTALLED ARE TO HAVE A METERED MULE TAPE PULL CORD INSTALLED.

dish
wireless.

5701 SOUTH SANTA FE DRIVE

LITTLETON, CO 80120

nb+c
TOTALLY COMMITTED.

nb+c ENGINEERING SERVICES, L.L.C.

300 UNICORN PARK DRIVE

SUITE 0501

WOBBURN, MA 01801

(978) 856-8308



IT IS A VIOLATION OF LAW FOR ANY PERSON, UNLESS THEY ARE ACTING UNDER THE DIRECTION OF A LICENSED PROFESSIONAL ENGINEER, TO ALTER THIS DOCUMENT.

DRAWN BY: CHECKED BY: APPROVED BY:

CWE

NSB

DRG

RDS REV #:

0

CONSTRUCTION DOCUMENTS

SUBMITTALS

REV

DATE

DESCRIPTION

0 01/11/24 ISSUED FOR CONSTRUCTION

1 08/07/24 REVISED UTILITY ROUTING

2 03/14/25 REVISED PER COMMENTS

A&E PROJECT NUMBER

100753

DISH Wireless L.L.C.

PROJECT INFORMATION

BOBOS00341B

1 BRATTLE SQUARE

CAMBRIDGE, MA 02138

SHEET TITLE

GENERAL NOTES

SHEET NUMBER

GN-4

GROUNDING NOTES:

1. ALL GROUND ELECTRODE SYSTEMS (INCLUDING TELECOMMUNICATION, RADIO, LIGHTNING PROTECTION AND AC POWER GES'S) SHALL BE BONDED TOGETHER AT OR BELOW GRADE, BY TWO OR MORE COPPER BONDING CONDUCTORS IN ACCORDANCE WITH THE NEC.
2. THE CONTRACTOR SHALL PERFORM IEEE FALL-OF-POTENTIAL RESISTANCE TO EARTH TESTING (PER IEEE 1100 AND 81) FOR GROUND ELECTRODE SYSTEMS, THE CONTRACTOR SHALL FURNISH AND INSTALL SUPPLEMENTAL GROUND ELECTRODES AS NEEDED TO ACHIEVE A TEST RESULT OF 5 OHMS OR LESS.
3. THE CONTRACTOR IS RESPONSIBLE FOR PROPERLY SEQUENCING GROUNDING AND UNDERGROUND CONDUIT INSTALLATION AS TO PREVENT ANY LOSS OF CONTINUITY IN THE GROUNDING SYSTEM OR DAMAGE TO THE CONDUIT AND PROVIDE TESTING RESULTS.
4. METAL CONDUIT AND TRAY SHALL BE GROUNDED AND MADE ELECTRICALLY CONTINUOUS WITH LISTED BONDING FITTINGS OR BY BONDING ACROSS THE DISCONTINUITY WITH #6 COPPER WIRE UL APPROVED GROUNDING TYPE CONDUIT CLAMPS.
5. METAL RACEWAY SHALL NOT BE USED AS THE NEC REQUIRED EQUIPMENT GROUND CONDUCTOR. STRANDED COPPER CONDUCTORS WITH GREEN INSULATION, SIZED IN ACCORDANCE WITH THE NEC, SHALL BE FURNISHED AND INSTALLED WITH THE POWER CIRCUITS TO BTS EQUIPMENT.
6. EACH CABINET FRAME SHALL BE DIRECTLY CONNECTED TO THE MASTER GROUND BAR WITH GREEN INSULATED SUPPLEMENTAL EQUIPMENT GROUND WIRES, #6 STRANDED COPPER OR LARGER FOR INDOOR BTS; #2 BARE SOLID TINNED COPPER FOR OUTDOOR BTS.
7. CONNECTIONS TO THE GROUND BUS SHALL NOT BE DOUBLED UP OR STACKED BACK TO BACK CONNECTIONS ON OPPOSITE SIDE OF THE GROUND BUS ARE PERMITTED.
8. ALL EXTERIOR GROUND CONDUCTORS BETWEEN EQUIPMENT/GROUND BARS AND THE GROUND RING SHALL BE #2 SOLID TINNED COPPER UNLESS OTHERWISE INDICATED.
9. ALUMINUM CONDUCTOR OR COPPER CLAD STEEL CONDUCTOR SHALL NOT BE USED FOR GROUNDING CONNECTIONS.
10. USE OF 90° BENDS IN THE PROTECTION GROUNDING CONDUCTORS SHALL BE AVOIDED WHEN 45° BENDS CAN BE ADEQUATELY SUPPORTED.
11. EXOTHERMIC WELDS SHALL BE USED FOR ALL GROUNDING CONNECTIONS BELOW GRADE.
12. ALL GROUND CONNECTIONS ABOVE GRADE (INTERIOR AND EXTERIOR) SHALL BE FORMED USING HIGH PRESS CRIMPS.
13. COMPRESSION GROUND CONNECTIONS MAY BE REPLACED BY EXOTHERMIC WELD CONNECTIONS.
14. ICE BRIDGE BONDING CONDUCTORS SHALL BE EXOTHERMICALLY BONDED OR BOLTED TO THE BRIDGE AND THE TOWER GROUND BAR.
15. APPROVED ANTIOXIDANT COATINGS (i.e. CONDUCTIVE GEL OR PASTE) SHALL BE USED ON ALL COMPRESSION AND BOLTED GROUND CONNECTIONS.
16. ALL EXTERIOR GROUND CONNECTIONS SHALL BE COATED WITH A CORROSION RESISTANT MATERIAL.
17. MISCELLANEOUS ELECTRICAL AND NON-ELECTRICAL METAL BOXES, FRAMES AND SUPPORTS SHALL BE BONDED TO THE GROUND RING, IN ACCORDANCE WITH THE NEC.
18. BOND ALL METALLIC OBJECTS WITHIN 6 ft OF MAIN GROUND RING WITH (1) #2 BARE SOLID TINNED COPPER GROUND CONDUCTOR.
19. GROUND CONDUCTORS USED FOR THE FACILITY GROUNDING AND LIGHTNING PROTECTION SYSTEMS SHALL NOT BE ROUTED THROUGH METALLIC OBJECTS THAT FORM A RING AROUND THE CONDUCTOR, SUCH AS METALLIC CONDUITS, METAL SUPPORT CLIPS OR SLEEVES THROUGH WALLS OR FLOORS. WHEN IT IS REQUIRED TO BE HOUSED IN CONDUIT TO MEET CODE REQUIREMENTS OR LOCAL CONDITIONS, NON-METALLIC MATERIAL SUCH AS PVC CONDUIT SHALL BE USED. WHERE USE OF METAL CONDUIT IS UNAVOIDABLE (i.e., NONMETALLIC CONDUIT PROHIBITED BY LOCAL CODE) THE GROUND CONDUCTOR SHALL BE BONDED TO EACH END OF THE METAL CONDUIT.
20. ALL GROUNDS THAT TRANSITION FROM BELOW GRADE TO ABOVE GRADE MUST BE #2 BARE SOLID TINNED COPPER IN 3/4" NON-METALLIC, FLEXIBLE CONDUIT FROM 24" BELOW GRADE TO WITHIN 3" TO 6" OF CAD-WELD TERMINATION POINT. THE EXPOSED END OF THE CONDUIT MUST BE SEALED WITH SILICONE CAULK. (ADD TRANSITIONING GROUND STANDARD DETAIL AS WELL).
21. BUILDINGS WHERE THE MAIN GROUNDING CONDUCTORS ARE REQUIRED TO BE ROUTED TO GRADE, THE CONTRACTOR SHALL ROUTE TWO GROUNDING CONDUCTORS FROM THE ROOFTOP, TOWERS, AND WATER TOWERS GROUNDING RING, TO THE EXISTING GROUNDING SYSTEM, THE GROUNDING CONDUCTORS SHALL NOT BE SMALLER THAN 2/0 COPPER. ROOFTOP GROUNDING RING SHALL BE BONDED TO THE EXISTING GROUNDING SYSTEM, THE BUILDING STEEL COLUMNS, LIGHTNING PROTECTION SYSTEM, AND BUILDING MAIN WATER LINE (FERROUS OR NONFERROUS METAL PIPING ONLY). DO NOT ATTACH GROUNDING TO FIRE SPRINKLER SYSTEM PIPES.

dish
wireless.

5701 SOUTH SANTA FE DRIVE
LITTLETON, CO 80120

NB+C
TOTALLY COMMITTED.

NB+C ENGINEERING SERVICES, LLC.

300 UNICORN PARK DRIVE
SUITE 0501
WOBURN, MA 01801
(978) 856-8308



IT IS A VIOLATION OF LAW FOR ANY PERSON, UNLESS THEY ARE ACTING UNDER THE DIRECTION OF A LICENSED PROFESSIONAL ENGINEER, TO ALTER THIS DOCUMENT.

DRAWN BY: CHECKED BY: APPROVED BY:

CWE NSB DRG

RFDS REV #: 0

CONSTRUCTION
DOCUMENTS

SUBMITTALS		
REV	DATE	DESCRIPTION
0	01/11/24	ISSUED FOR CONSTRUCTION
1	08/07/24	REVISED UTILITY ROUTING
2	03/14/25	REVISED PER COMMENTS

A&E PROJECT NUMBER

100753

DISH Wireless L.L.C.
PROJECT INFORMATION

BOBOS00341B

1 BRATTLE SQUARE
CAMBRIDGE, MA 02138

SHEET TITLE

GENERAL NOTES

SHEET NUMBER

GN-5

NOTE:
CONTRACTOR SHALL FIELD VERIFY ALL DIMENSIONS PRIOR TO MATERIAL BIDDING, MATERIAL ORDERS, AND FABRICATION.
CONTRACTOR SHALL COORDINATE WITH BUILDING OWNERS APPROVED ROOFER FOR ALL PENETRATIONS,
WEATHERPROOFING AND SEALING. CONTRACTOR SHALL ENSURE ROOF MEMBRANE WARRANTY IS MAINTAINED, AS
APPLICABLE AND PER ROOF MEMBRANE MANUFACTURER SPECIFICATIONS.

NOTE: X DENOTES A DOCUMENT NEEDED FOR THE PMI REPORT
N/A DENOTES A DOCUMENT THAT IS NOT REQUIRED FOR THE PMI REPORT

PMI CHECKLIST	
CONSTRUCTION/INSTALLATION INSPECTIONS AND TESTING REQUIRED	REPORT ITEM
PRE-CONSTRUCTION	
X	PMI CHECKLIST DRAWING
X	EOR APPROVED SHOP DRAWINGS
N/A	FABRICATION INSPECTION
N/A	FABRICATOR CERTIFIED WELD INSPECTION
N/A	MATERIAL TEST REPORT (MTR)
N/A	FABRICATOR NDE INSPECTION
N/A	NDE REPORT OF MONOPOLE BASE PLATE (AS REQUIRED)
X	PACKING SLIPS
ADDITIONAL TESTING AND INSPECTIONS:	
CONSTRUCTION	
X	CONSTRUCTION INSPECTIONS
N/A	FOUNDATION INSPECTIONS
N/A	CONCRETE COMP. STRENGTH AND SLUMP TESTS
N/A	POST INSTALLED ANCHOR ROD VERIFICATION
N/A	BASE PLATE GROUT VERIFICATION
N/A	CONTRACTOR'S CERTIFIED WELD INSPECTION
N/A	EARTHWORK, LIFT AND DENSITY
N/A	ON SITE COLD GALVANIZING VERIFICATION
N/A	GUY WIRE TENSION REPORT
X	GC AS-BUILT DOCUMENTS
ADDITIONAL TESTING AND INSPECTIONS:	
POST-CONSTRUCTION	
X	PMI INSPECTOR REDLINE OR RECORD DRAWING(S)
N/A	POST INSTALLED ANCHOR ROD PULL-OUT TESTING
X	PHOTOGRAPHS
ADDITIONAL TESTING AND INSPECTIONS:	

POST MODIFICATION INSPECTION NOTES:

- GENERAL**
- THE POST MODIFICATION INSPECTION (PMI) IS A VISUAL INSPECTION OF TOWER MODIFICATIONS AND A REVIEW OF CONSTRUCTION INSPECTIONS AND OTHER REPORTS TO ENSURE THE INSTALLATION WAS CONSTRUCTED IN ACCORDANCE WITH THE CONTRACT DOCUMENTS, NAMELY THE MODIFICATION DRAWINGS, AS DESIGNED BY THE ENGINEER OF RECORD (EOR).
 - THE PMI IS TO CONFIRM INSTALLATION CONFIGURATION AND WORKMANSHIP ONLY AND IS NOT A REVIEW OF THE MODIFICATION DESIGN ITSELF. NOR DOES THE PMI INSPECTOR TAKE OWNERSHIP OF THE MODIFICATION DESIGN. OWNERSHIP OF THE STRUCTURAL MODIFICATION DESIGN EFFECTIVENESS AND INTEGRITY RESIDES WITH THE EOR AT ALL TIMES.
 - ALL PMI'S SHALL BE CONDUCTED BY A PMI INSPECTOR THAT IS APPROVED TO PERFORM ELEVATED WORK FOR NB+C ENGINEERING SERVICES, LLC.
 - TO ENSURE THAT THE REQUIREMENTS OF THE PMI ARE MET, IT IS VITAL THAT THE GENERAL CONTRACTOR (GC) AND THE PMI INSPECTOR BEGIN COMMUNICATING AND COORDINATING AS SOON AS A PO IS RECEIVED. IT IS EXPECTED THAT EACH PARTY WILL BE PROACTIVE IN REACHING OUT TO THE OTHER PARTY, IF CONTACT INFORMATION IS NOT KNOWN, CONTACT YOUR NB+C POINT OF CONTACT (POC).
 - REFER TO CCR-01 : CONTRACTOR CLOSEOUT REQUIREMENTS FOR FURTHER DETAILS AND REQUIREMENTS.
- PMI INSPECTOR**
- THE PMI INSPECTOR IS REQUIRED TO CONTACT THE GC AS SOON AS RECEIVING A PO FOR THE PMI TO, AT A MINIMUM:
 - REVIEW THE REQUIREMENTS OF THE PMI CHECKLIST
 - WORK WITH THE GC TO DEVELOP A SCHEDULE TO CONDUCT ON-SITE INSPECTIONS, INCLUDING FOUNDATION INSPECTIONS
 - THE PMI INSPECTOR IS RESPONSIBLE FOR COLLECTING ALL GENERAL CONTRACTOR (GC) INSPECTION AND TEST REPORTS, REVIEWING THE DOCUMENTS FOR ADHERENCE TO THE CONTRACT DOCUMENTS, CONDUCTING THE IN-FIELD INSPECTIONS, AND SUBMITTING THE PMI REPORT TO NB+C ENGINEERING SERVICES, LLC.
- CORRECTION OF FAILING PMI'S**
- IF THE MODIFICATION INSTALLATION WOULD FAIL THE PMI (FAILED PMI), THE GC SHALL WORK WITH THE ENGINEER OF RECORD TO COORDINATE A REMEDIATION PLAN IN ONE OF TWO WAYS:
 - CORRECT FAILING ISSUES TO COMPLY WITH THE SPECIFICATIONS CONTAINED IN THE ORIGINAL CONTRACT
 - OR, WITH EOR'S APPROVAL, THE GC MAY WORK WITH THE EOR TO RE-ANALYZE THE MODIFICATION/REINFORCEMENT USING THE AS-BUILT CONDITION.
 - BETWEEN THE GC AND THE PMI INSPECTOR THE FOLLOWING PHOTOGRAPHS, AT A MINIMUM, ARE TO BE TAKEN AND INCLUDED IN THE PMI REPORT:
 - PRE-CONSTRUCTION GENERAL SITE CONDITION
 - PHOTOGRAPHS DURING THE REINFORCEMENT MODIFICATION CONSTRUCTION/ERECTION AND INSPECTION
 - RAW MATERIALS
 - PHOTOS OF ALL CRITICAL DETAILS
 - WELD PREPARATION
 - BOLT INSTALLATION AND TORQUE
 - FINAL INSTALLED CONDITION
 - POST CONSTRUCTION PHOTOGRAPHS
 - FINAL INFIELD CONDITION
 - PHOTOS OF ELEVATED MODIFICATIONS TAKEN FROM THE GROUND SHALL BE CONSIDERED INADEQUATE.

GN-6		
SHEET NUMBER		
PMI CHECKLIST & NOTES		
SHEET TITLE		
1 BRATTLE SQUARE CAMBRIDGE, MA 02138		
BOBOS00341B PROJECT INFORMATION DISH Wireless L.L.C.		
100753		
A&E PROJECT NUMBER		
REV	DATE	
0	01/11/24	
1	08/07/24	
2	03/14/25	
ISSUED FOR CONSTRUCTION		
REVISED UTILITY ROUTING		
REVISED PER COMMENTS		
SUBMITTALS		
DESCRIPTION		
CONSTRUCTION DOCUMENTS		
RFD'S REV #:		
CWE	NSB	DRG
DRAWN BY: CHECKED BY: APPROVED BY:		
IT IS A VIOLATION OF LAW FOR ANY PERSON, UNLESS THEY ARE ACTING UNDER THE DIRECTION OF A LICENSED PROFESSIONAL ENGINEER, TO ALTER THIS DOCUMENT.		
		
300 UNICORN PARK DRIVE SUITE 0501 WOBURN, MA 01801 (978) 856-8308		
NB+C ENGINEERING SERVICES, LLC.		
TOTALLY COMMITTED.		
5701 SOUTH SANTA FE DRIVE LITTLETON, CO 80120		
dish wireless.		


STRUCTURAL NOTES

1. THE STRUCTURAL STEEL CONTRACTOR SHALL BE RESPONSIBLE FOR VERIFYING THE ANCHOR BOLT LOCATIONS, ELEVATION OF TOP OF CONCRETE AND BEARING PLATES, ALIGNMENT ETC. PRIOR TO START OF STEEL ERECTION.
2. THE LATEST EDITION OF THE FOLLOWING SPECIFICATIONS SHALL GOVERN:
A. AISC - "ALLOWABLE STRESS DESIGN SPECIFICATION FOR STRUCTURAL STEEL BUILDINGS".
B. AISC - "CODE OF STANDARD PRACTICE FOR STEEL BUILDINGS AND BRIDGES".
C. AWS - "D1.1 STRUCTURAL WELDING CODE - STEEL".
3. MATERIAL, UNLESS OTHERWISE NOTED, SHALL CONFORM TO THE FOLLOWING ASTM SPECIFICATIONS


STRUCTURAL WIDE FLANGE & M SHAPES	A992 OR A572
OTHER STRUCTURAL SHAPES AND PLATES	Fy = 50KSI
STRUCTURAL TUBING	A36, Fy = 36 KSI
	A500, GRADE B
	Fy = 46 KSI
HIGH STRENGTH BOLTS	A325
THREADED RODS	A354, GRADE BC
ANCHOR BOLTS	A325 OR A354 BC
PIPE (HANDRAIL)	SCH 40 PIPE
4. ALL WELDING SHALL BE IN ACCORDANCE WITH AWS D1.1 USING E70XX ELECTRODES. UNLESS OTHERWISE NOTED PROVIDE CONTINUOUS MINIMUM SIZED FILLET WELDS PER AISC REQUIREMENTS.
5. HOLES IN STEEL SHALL BE DRILLED OR PUNCHED. ALL SLOTTED HOLES SHALL BE PROVIDED WITH SMOOTH EDGES. BURNING OF HOLES AND TORCH CUTTING AT THE SITE IS NOT PERMITTED. ALL HOLES IN BEARING PLATES SHALL BE DRILLED.
6. ALL STEEL TO BE HOT-DIPPED GALVANIZED AFTER FABRICATION PER ASTM A123.
7. ALL BOLTS SHALL BE TIGHTENED USING TURN-OF-THE-NUT METHOD PER AISC SPECIFICATIONS USING STANDARD HOLES.
8. CONTRACTOR TO FIELD VERIFY ALL DIMENSIONS AND FIT PRIOR TO FABRICATION.
9. THE FABRICATOR SHALL FURNISH CHECKED SHOP AND ERECTION DRAWINGS TO THE ENGINEER, AND OBTAIN APPROVAL PRIOR TO FABRICATING ANY STRUCTURAL STEEL. SHOP DRAWINGS SHALL CONFORM TO AISC "DETAILING FOR STEEL CONSTRUCTION".

FRP STRUCTURAL MEMBERS

1. FRP STRUCTURAL SHAPES SHALL BE BEDFORD FRP SERIES 1525, MANUFACTURED USING THE PULTRUSION PROCESS.
2. IF PREFABRICATED MEMBERS DO NOT ASSEMBLE PER PLAN, CONTACT ENGINEER BEFORE CUTTING OR ALTERING FABRICATED MEMBERS.
3. FRP STRUCTURAL MEMBERS SHALL BE FABRICATED AND ASSEMBLED AS INDICATED ON THE DRAWINGS.
4. THE CONTRACTOR SHALL PROTECT THE FRP STRUCTURAL MEMBERS FROM ABUSE TO PREVENT BREAKAGE, NICKS, GOUGES, ETC. DURING FABRICATION, HANDLING, AND INSTALLATION.
5. FRP BOLTS SHOULD BE TIGHTENED 1/2 TURN PAST SNUG AND LOCKED WITH EPOXY.

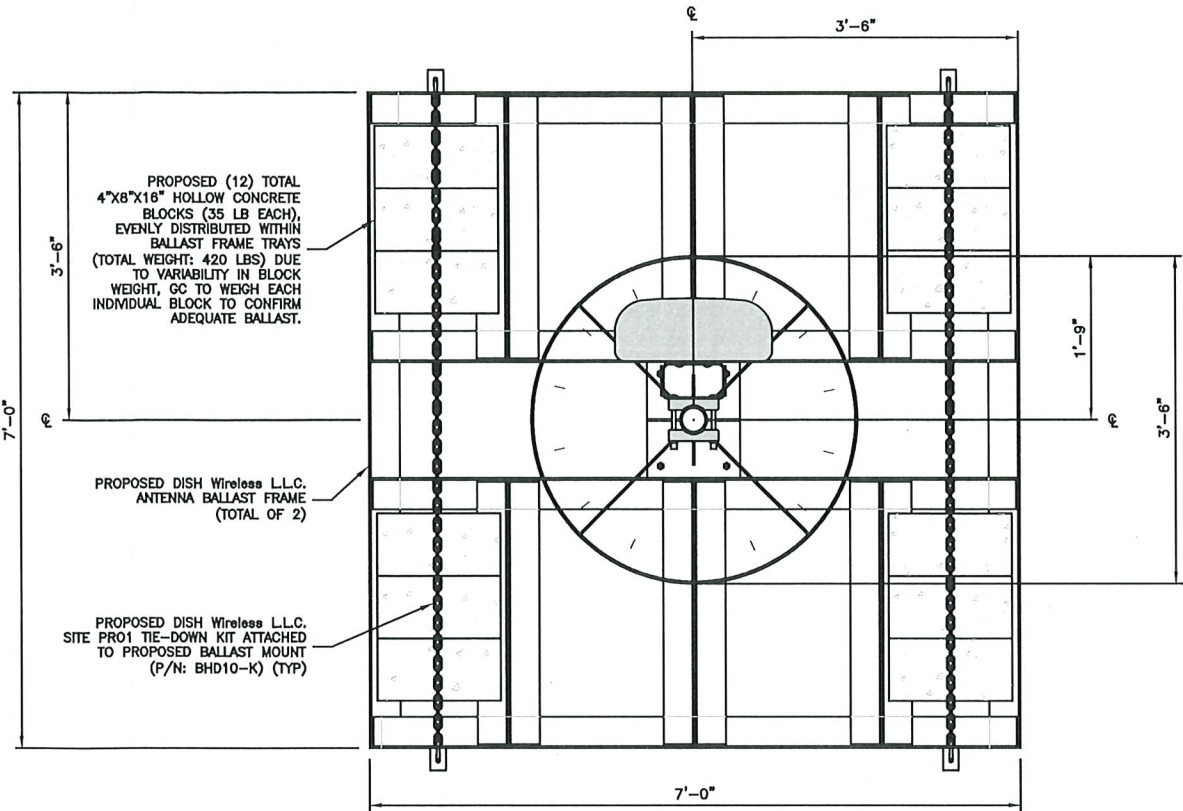


OVERALL BALLAST CONCEALMENT PLAN

 


1


NOTES

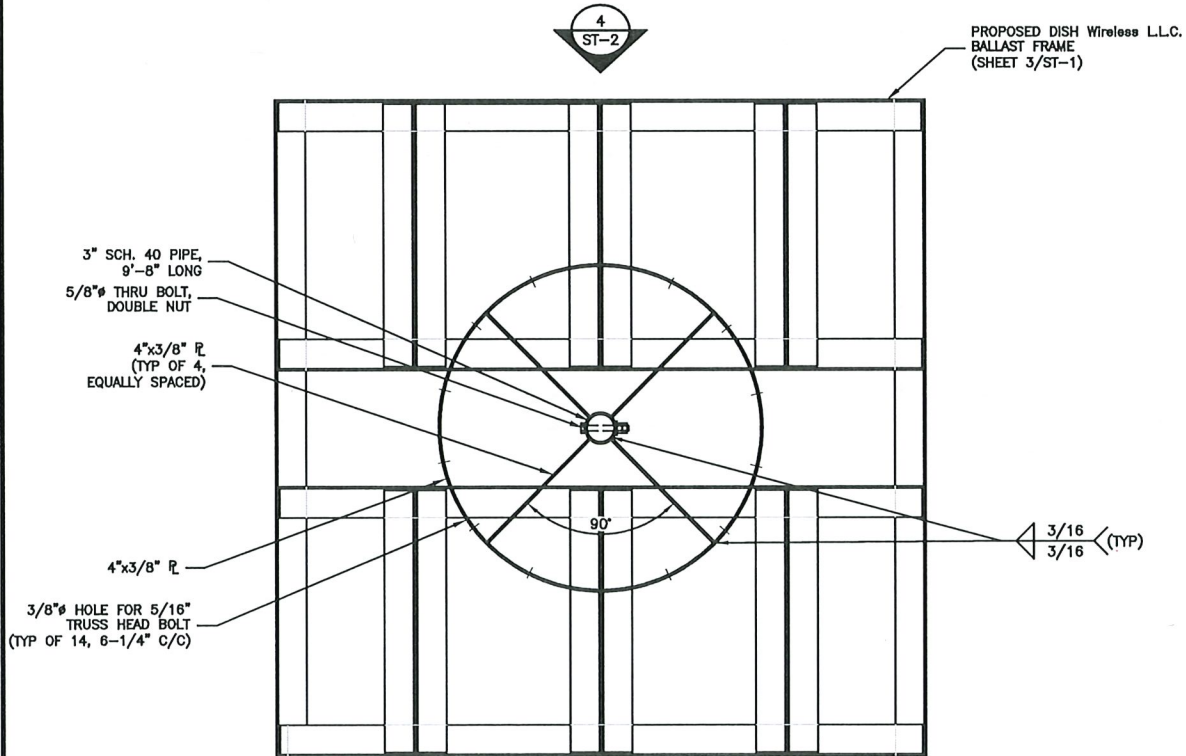


OVERALL CONCEALMENT PLAN

 

2

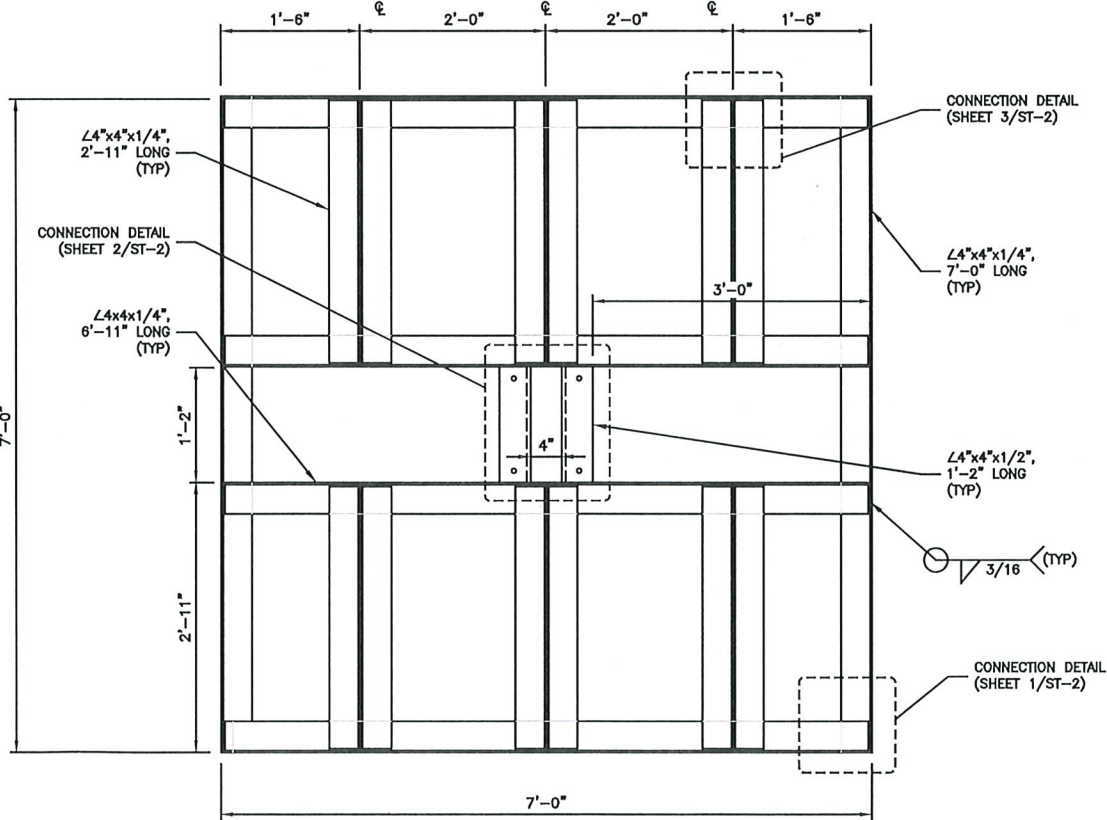

OVERALL BALLAST FRAME PLAN

 

3

dish
wireless.

5701 SOUTH SANTA FE DRIVE
LITTLETON, CO 80120

NB+C
TOTALLY COMMITTED.

NB+C ENGINEERING SERVICES, LLC.

300 UNICORN PARK DRIVE
SUITE 0501
WOBURN, MA 01801
(978) 856-8308



IT IS A VIOLATION OF LAW FOR ANY PERSON, UNLESS THEY ARE ACTING UNDER THE DIRECTION OF A LICENSED PROFESSIONAL ENGINEER, TO ALTER THIS DOCUMENT.

DRAWN BY: CHECKED BY: APPROVED BY:

CWE NSB DRG

RFDS REV #: 0

CONSTRUCTION
DOCUMENTS

SUBMITTALS		
REV	DATE	DESCRIPTION
0	01/11/24	ISSUED FOR CONSTRUCTION
1	08/07/24	REVISED UTILITY ROUTING
2	03/14/25	REVISED PER COMMENTS

A&E PROJECT NUMBER

100753

DISH Wireless L.L.C.
PROJECT INFORMATION


BOBOS00341B

1 BRATTLE SQUARE
CAMBRIDGE, MA 02138


SHEET TITLE
ANTENNA BALLAST FRAME
& CONCEALMENT PLAN

SHEET NUMBER


ST-1

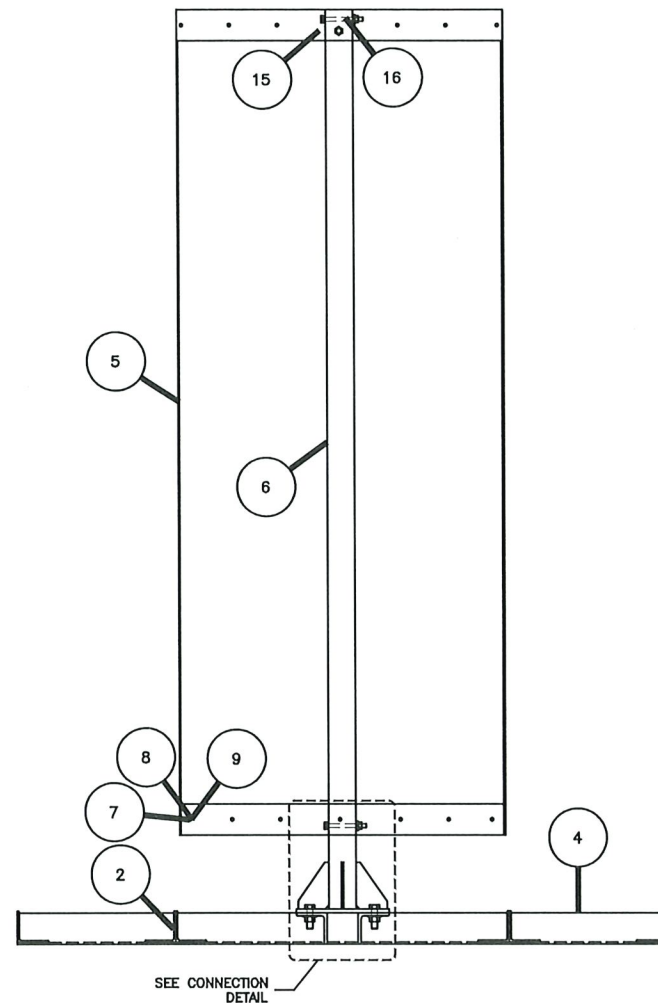


CONCEALMENT ELEVATION

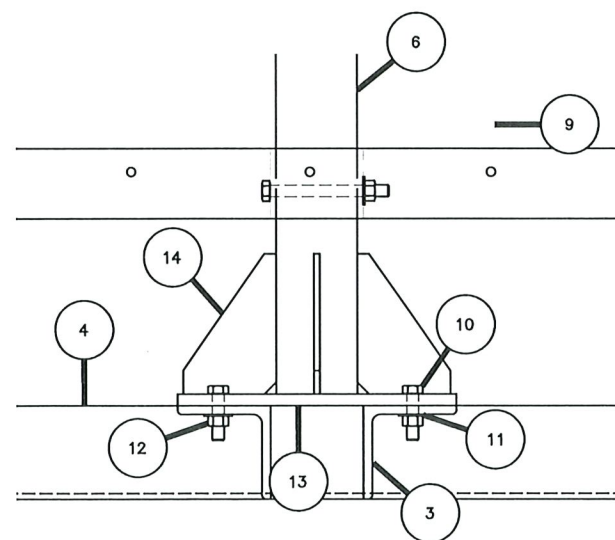

CONNECTION DETAIL

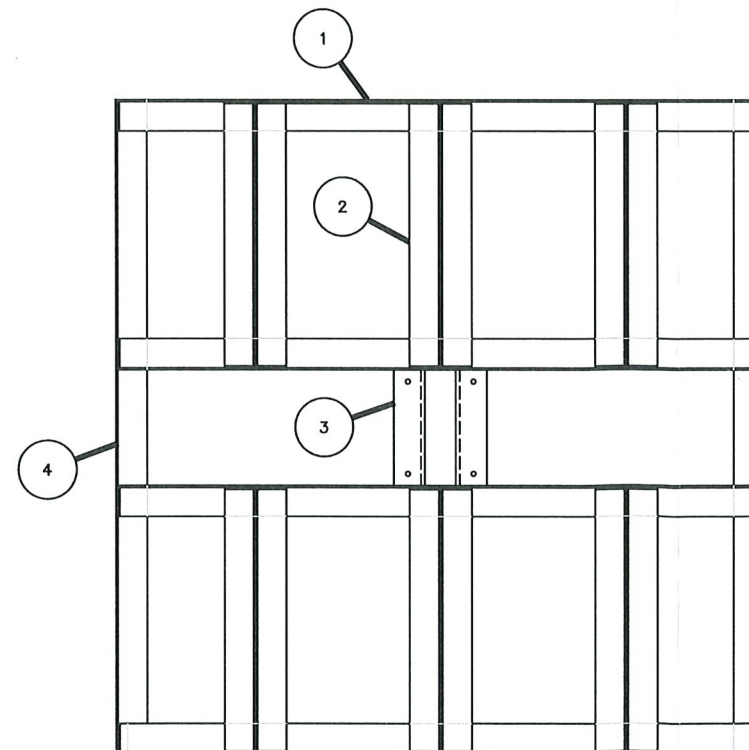

OVERALL BALLAST FRAME PLAN

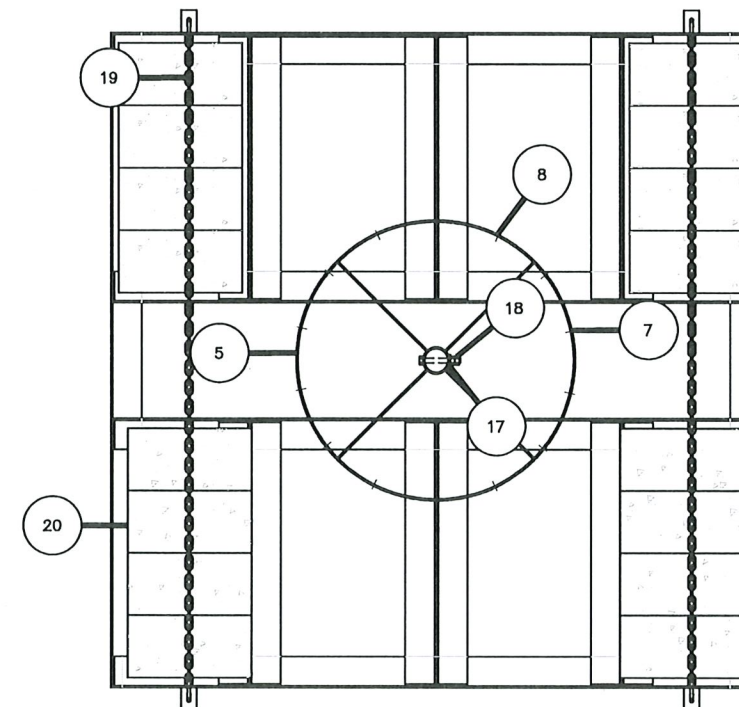

OVERALL CONCEALMENT PLAN

ITEM #	DESCRIPTION	SIZE	LENGTH	Part Number	QTY
1	Steel Angle	4"x4"x1/4"	6'-11"	N/A	4
2	Steel Angle	4"x4"x1/4"	2'-11"	N/A	12
3	Steel Angle	4"x4"x1/2"	1'-2"	N/A	2
4	Steel Angle	4"x4"x1/4"	7'-0"	N/A	2
5	ABS Cylinder	3'-6"x3/16"	8'-10"	N/A	1
6	Steel Pipe	3" SCH 40	9'-7"	N/A	1
7	Truss Head Bolt	5/16"Ø	1"	N/A	28
8	Washer	5/16"Ø	N/A	N/A	28
9	Hex Nut	5/16"Ø	N/A	N/A	28
10	A325 Bolt	1/2"Ø	2"	N/A	4
11	Washer	1/2"Ø	N/A	N/A	4
12	Hex Nut	1/2"Ø	N/A	N/A	4
13	Steel Plate	1'-2"x1'-0"x1/2"	N/A	N/A	1
14	Gusset Plate	6"x4"x1/4"	N/A	N/A	4
15	Steel HSS Pipe	4"x0.22"	4"	N/A	2
16	Bolt, Thru	5/8"Ø	4"	N/A	2
17	Washer	5/8"Ø	N/A	N/A	2
18	Hex Nut	5/8"Ø	N/A	N/A	4
19	Tie-Down Kit	N/A	N/A	SitePro1 BHD10-K	2
20	Hollow Conc. Block	8"x8"x16"	N/A	N/A	12

dish
wireless.

5701 SOUTH SANTA FE DRIVE
LITTLETON, CO 80120

NB+C
TOTALLY COMMITTED.

NB+C ENGINEERING SERVICES, LLC.

300 UNICORN PARK DRIVE
SUITE 0501
WOBBURN, MA 01801
(978) 856-8308



IT IS A VIOLATION OF LAW FOR ANY PERSON,
UNLESS THEY ARE ACTING UNDER THE DIRECTION
OF A LICENSED PROFESSIONAL ENGINEER,
TO ALTER THIS DOCUMENT.

DRAWN BY: CHECKED BY: APPROVED BY:

CWE NSB DRG

RFDS REV #: 0

CONSTRUCTION DOCUMENTS

SUBMITTALS		
REV	DATE	DESCRIPTION
0	01/11/24	ISSUED FOR CONSTRUCTION
1	08/07/24	REVISED UTILITY ROUTING
2	03/14/25	REVISED PER COMMENTS

A&E PROJECT NUMBER

100753

DISH Wireless L.L.C.
PROJECT INFORMATION
BOBOS00341B

1 BRATTLE SQUARE
CAMBRIDGE, MA 02138

SHEET TITLE
BILL OF MATERIALS

SHEET NUMBER

ST-3

